



GREGORY STREET LIGHTING

VILLAGE OF MOUNT PROSPECT, ILLINOIS

SHEET NO.	DESCRIPTION
1	COVER SHEET, INDEX OF SHEETS
2	GENERAL NOTES, LEGEND, SUMMARY OF QUANTITIES
3-11	LIGHTING DETAILS
12-15	LIGHTING PLANS
16-17	SINGLE LINE DIAGRAM

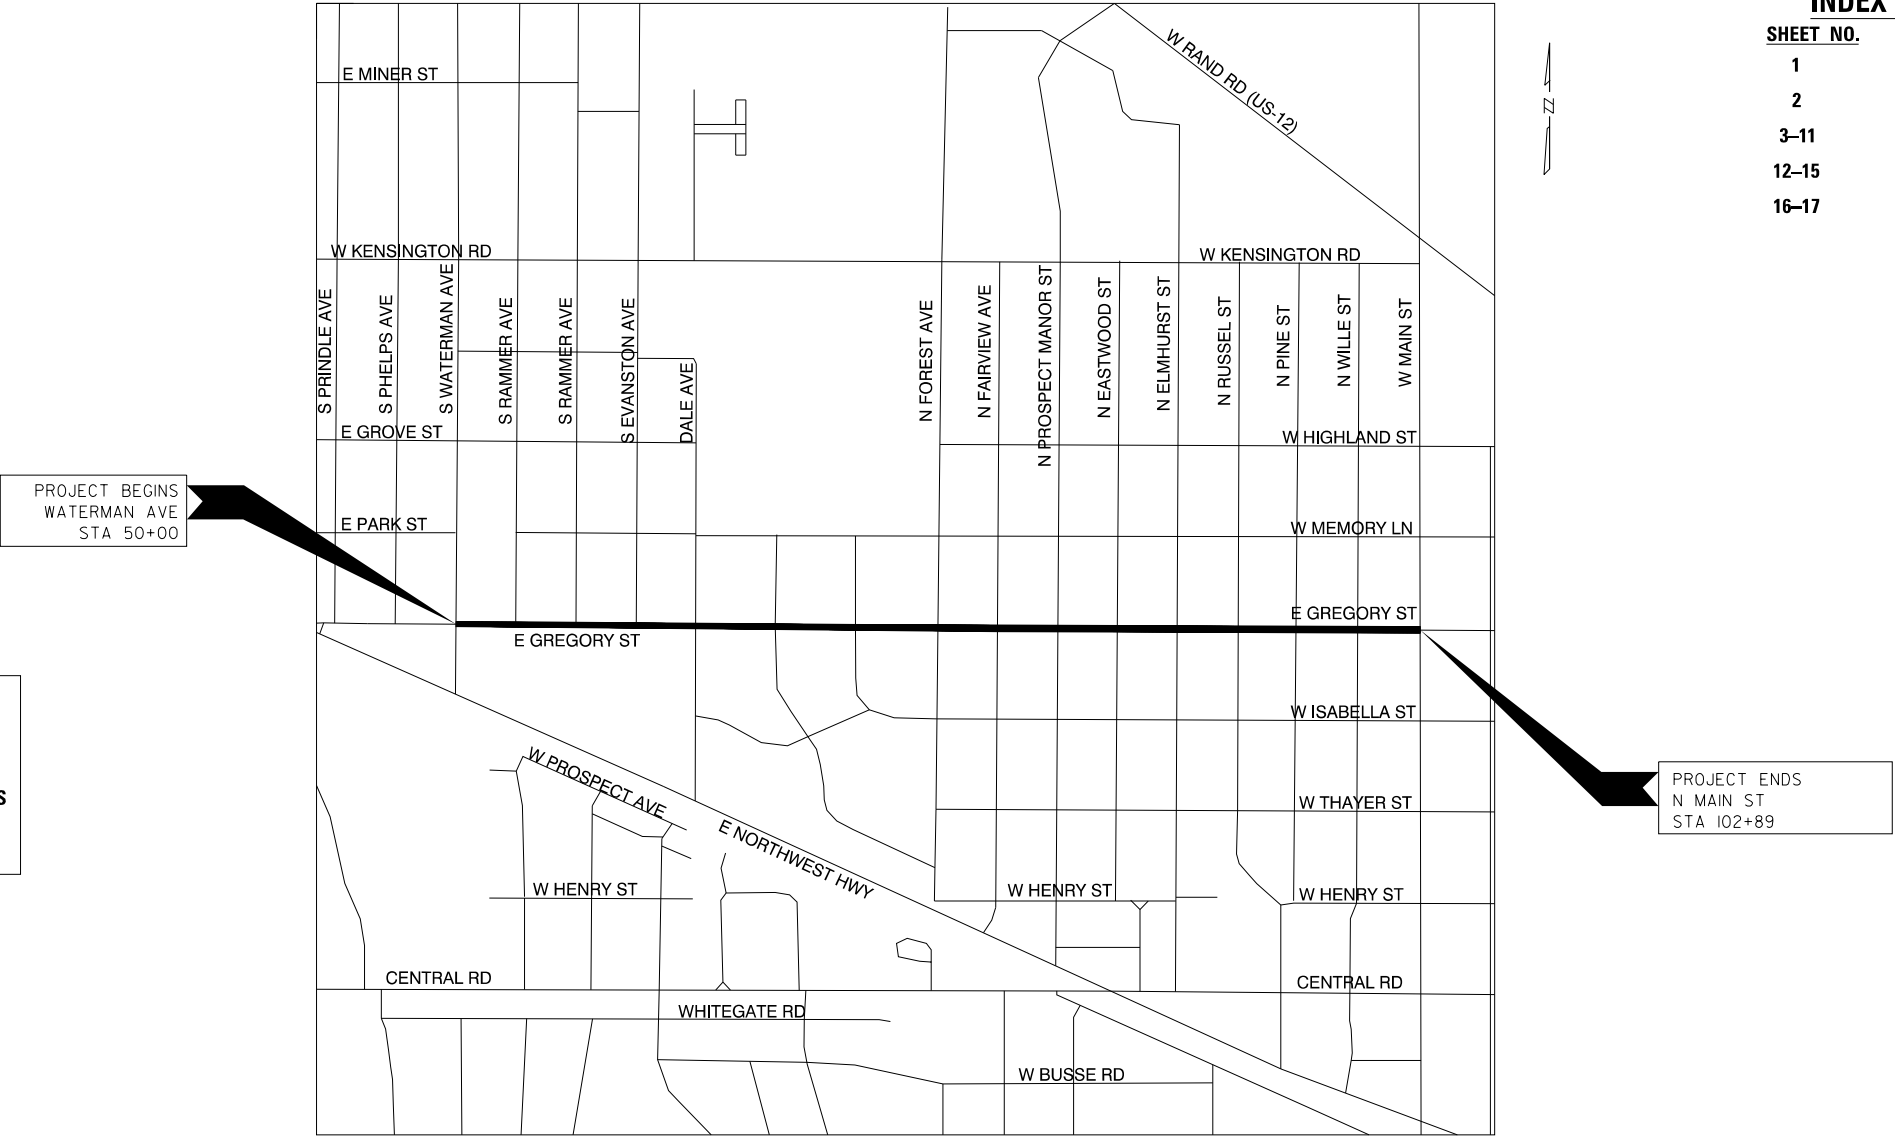

THE CONTRACTOR WILL NOT BE ALLOWED TO COMMENCE CONSTRUCTION UNTIL CERTIFICATES OF INSURANCE INDEMNIFYING AS ADDITIONAL INSURED PARTIES THE VILLAGE OF MOUNT PROSPECT AND THE CONSULTING ENGINEER, CIORBA GROUP, INC., 8725, SUITE 600, W. HIGGINS ROAD, CHICAGO, ILLINOIS 60631, HAVE BEEN DELIVERED TO AND APPROVED BY CIORBA GROUP, INC.

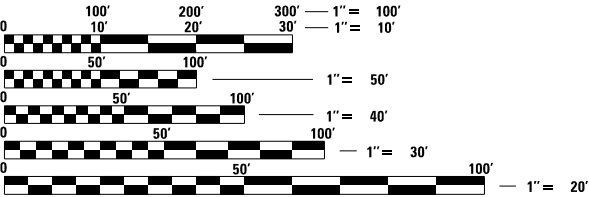

FULL SIZE PLANS HAVE BEEN PREPARED USING STANDARD ENGINEERING SCALES. REDUCED SIZED PLANS WILL NOT CONFORM TO STANDARD SCALES. IN MAKING MEASUREMENTS ON REDUCED PLANS, THE ABOVE SCALES MAY BE USED.

J.U.L.I.E.
JOINT UTILITY LOCATION INFORMATION FOR EXCAVATION
1-800-892-0123
OR 811

LOCATION MAP
(NOT TO SCALE)
GROSS LENGTH = 5,288 FEET (1.00 MILES)
NET LENGTH = 5,288 FEET (1.00 MILES)



DATE: 7/2/2026
SEAL EXPIRES: 11/30/2027
SIGNED: *Joseph M. Vondra*



CiorbaGroup
CONSULTING ENGINEERS

DESIGN FIRM REGISTRATION NUMBER: 184-001016
8725 W. Higgins Road, Suite 600 | Chicago, IL 60631
P 773.775.4009 | www.ciorba.com

ACCESS

THE CONTRACTOR WILL BE REQUIRED TO MAINTAIN INGRESS AND EGRESS FOR EMERGENCY VEHICLES AT ALL TIMES DURING THE CONSTRUCTION PERIOD. DURING CONSTRUCTION, GARBAGE TRUCKS MUST BE PERMITTED ACCESS TO THE WORK ZONE IN ORDER TO PICK UP COMMERCIAL GARBAGE FOR THOSE PROPERTIES IMPACTED BY CONSTRUCTION. IF GARBAGE TRUCKS ACCESS IS NOT PROVIDED, THE CONTRACTOR WILL BE REQUIRED TO MOVE TRASH CONTAINERS TO AN ACCESSIBLE LOCATION.

UNDERGROUND UTILITIES

THE LOCATIONS OF THE UNDERGROUND UTILITIES AS SHOWN ON THE PLANS HAVE BEEN OBTAINED BY FIELD SURVEYS AND SEARCHES OF AVAILABLE RECORDS. IT IS BELIEVED THAT THE DATA IS ESSENTIALLY CORRECT, BUT THE VILLAGE OF MOUNT PROSPECT, AND/OR OTHER OFFICES AND AGENCIES ASSOCIATED WITH THE DEVELOPMENT OF THESE PLANS DO NOT GUARANTEE THEIR ACCURACY OR COMPLETENESS. THE CONTRACTOR WILL BE REQUIRED TO VERIFY THE LOCATION OF EACH FACILITY WITH THE UTILITY COMPANY, AND SHALL TAKE DUE CARE IN ALL PHASES OF THE CONSTRUCTION TO PROTECT ANY SUCH FACILITIES WHICH MAY BE AFFECTED BY THE WORK. ANY DAMAGE TO THE EXISTING UTILITIES SHALL BE REPAIRED IN ACCORDANCE WITH ARTICLE LR 105.

ADJUSTMENTS REQUIRED BY UTILITY COMPANIES WILL BE PERFORMED BY THE COMPANY INVOLVED OR ITS CONTRACTOR, BUT WILL BE COORDINATED BY THE GENERAL CONTRACTOR.

COORDINATION OF ALL UTILITY WORK INVOLVED IN THE CONSTRUCTION AREA WILL BE DISCUSSED AT A PRE-CONSTRUCTION CONFERENCE.

THE CONTRACTOR SHALL USE EXTREME CAUTION IN THE REMOVAL OF ABANDONED EXISTING GAS LINES SINCE RESIDUAL MATERIALS CONTAINED THEREIN ARE HIGHLY EXPLOSIVE, FLAMMABLE, AND TOXIC. ONCE THE MAINS ARE ABANDONED BY THE OWNER, THE CONTRACTOR SHALL ASSUME ALL RESPONSIBILITY FOR ANY DAMAGE AND/OR INJURY OCCURRING ON THE PROJECT DUE TO HIS OPERATIONS NEXT TO THE MAINS AND/OR THE METHOD OF REMOVAL OF THE ABANDONED MAINS.

OPEN EXCAVATION

THE CONTRACTOR WILL NOT BE ALLOWED TO LEAVE EXCAVATIONS OPEN OVERNIGHT. THE CONTRACTOR WILL BE RESPONSIBLE FOR COMPLETELY BACKFILLING OR PLATING OVER ALL EXCAVATIONS AT THE END OF EACH DAY. IF THE EXCAVATIONS ARE BACKFILLED THEY SHALL BE FILLED WITH AN AGGREGATE MEETING THE GRADATION OF CA-6. THE MATERIAL WILL BE COMPACTED SUFFICIENTLY TO PREVENT RUTTING OR SETTLEMENT OF MATERIALS UNDER TRAFFIC LOADS. IF PLATES ARE USED THEY SHALL BE OF SUFFICIENT THICKNESS TO SUPPORT VEHICULAR LOADS. ADDITIONALLY THEY SHALL EXTEND A MINIMUM OF NINE INCHES (9") BEYOND THE LIMITS OF THE EXCAVATION ON ALL SIDES. IF THE PLATES ARE TO BE LEFT OVER THE WEEKEND, THE EDGES OF THE PLATES SHALL BE CUSHIONED WITH A BITUMINOUS MIXTURE IN AREAS WHERE VEHICULAR TRAFFIC WILL CROSS THE PLATES.

THE COST FOR PROVIDING THE AGGREGATE, PLATES AND BITUMINOUS MIXTURE WILL NOT BE PAID FOR DIRECTLY BUT SHALL BE INCLUDED IN THE VARIOUS CONTRACT ITEMS.

TREE PROTECTION

THE CONTRACTOR SHALL BE RESPONSIBLE FOR BEING FAMILIAR WITH AND COMPLYING WITH ALL ASPECTS OF THE VILLAGE OF MOUNT PROSPECT TREE PROTECTION ORDINANCES AND ARBORICULTURAL STANDARDS MANUAL.

STREET SIGNS

IF ANY STREET SIGNS ARE DAMAGED DURING CONSTRUCTION THEY SHALL BE REPLACED AT THE CONTRACTOR'S EXPENSE.

MAINTENANCE OF EXISTING DRAINAGE STRUCTURES

LOOSE MATERIAL THAT IS DEPOSITED IN THE FLOW LINE OF GUTTERS OR DRAINAGE STRUCTURES THAT INHIBITS THE NATURAL FLOW OF WATER SHALL BE REMOVED AT THE CLOSE OF EACH WORKING DAY. AT THE CONCLUSION OF THE CONSTRUCTION OPERATIONS, ALL DRAINAGE FACILITIES SHALL BE CLEAN AND FREE OF ALL OBSTRUCTIONS. THE COST OF THIS WORK SHALL BE INCLUDED IN THE VARIOUS CONTRACT ITEMS.

SAW CUTTING

THE CONTRACTOR SHALL SAW CUT ASPHALT PAVEMENT AND CONCRETE PAVEMENT AS INDICATED ON THE PLANS OR AS DIRECTED BY THE ENGINEER, TO SEPARATE THE EXISTING PAVEMENT TO BE REMOVED BY MEANS OF AN APPROVED CONCRETE SAW TO A DEPTH AS DIRECTED BY THE ENGINEER. SUITABLE GUIDELINES OR DEVICES SHALL BE USED TO ASSURE CUTTING A NEAT, STRAIGHT LINE AS SHOWN ON THE PLANS. CARE SHALL BE TAKEN BY THE CONTRACTOR SO AS NOT TO DAMAGE THE REMAINING PAVEMENT DIRECTLY ADJACENT TO THE PAVEMENT TO BE REMOVED. ANY DAMAGE TO THE EXISTING PAVEMENT RESULTING FROM PAVEMENT REMOVAL OPERATIONS SHALL BE REPAIRED AT THE CONTRACTOR'S EXPENSE. THE PRICE OF SAW CUTTING, AS NOTED ABOVE, SHALL BE INCLUDED IN THE PARTICULAR PAY ITEMS.

TRAFFIC PROTECTION

WHEN WORK COMMENCES, THE CONTRACTOR SHALL ASSUME THE MAINTENANCE OF ALL PAVEMENT, SHOULDERS, DRAINAGE FACILITIES, TRAFFIC CONTROL SIGNS, PAVEMENT MARKING, AND OTHER APPURTENANCES ON ROADWAYS WITHIN THE LIMITS OF THE CONTRACT WHICH ARE TO BE USED BY THE PUBLIC DURING CONSTRUCTION AND TO RETAIN THIS MAINTENANCE RESPONSIBILITY UNTIL PROJECT COMPLETION. NEED FOR SNOW AND ICE CONTROL DURING THE CONSTRUCTION PERIOD SHALL BE ACCOMMODATED FOR BY OTHERS. ALL UNBALLASTED TYPE I & II BARRICADES SHALL HAVE TWO SANDBAGS ONE ACROSS EACH BOTTOM RAIL.

SUMARY OF QUANTITIES

PAY ITEM NO.	DESCRIPTION	UNIT	QUANTITY
1	UNDERGROUND CONDUIT, GALVANIZED STEEL, 2"	FOOT	42
2	UNDERGROUND CONDUIT, GALVANIZED STEEL, 3"	FOOT	873
3	UNIT DUCT, 600V, 2-1C NO.6, 1/C NO.8 GROUND, (XLP-TYPE USE), 1" DIA. POLYETHYLENE	FOOT	5,529
4	ELECTRIC CABLE IN CONDUIT, 600V (XLP-TYPE USE), 1/C NO. 2	FOOT	210
5	LIGHT STANDARD, ALUMINUM, 25' M.H., 10 FT. CLAMP-ON MAST ARM, LED LUMINAIRE	EACH	14
6	LIGHT STANDARD, ALUMINUM, 25' M.H., 12 FT. CLAMP-ON MAST ARM, LED LUMINAIRE	EACH	4
7	LIGHT STANDARD, ALUMINUM, 25' M.H., 15 FT. CLAMP-ON MAST ARM, LED LUMINAIRE	EACH	1
8	ELECTRIC UTILITY SERVICE CONNECTION (COMED)	L SUM	1
9	ELECTRIC SERVICE INSTALLATION	EACH	1
10	LIGHTING CONTROLLER	EACH	1
11	BREAKAWAY DEVICE WITH ALUMINUM SKIRT	EACH	19
12	LIGHT POLE FOUNDATION, METAL, 11" BOLT CIRCLE, 8 5/8" X 6'	EACH	19
* 13	TREE PROTECTION FENCE	FOOT	500
* 14	COMBINATION CONCRETE CURB AND GUTTER REMOVAL AND REPLACEMENT	FOOT	10
15	TRAFFIC CONTROL AND PROTECTION	L SUM	1
16	ELECTRICAL HANDHOLE	EACH	1
* 17	CLASS D PATCHES, SPECIAL	SQ YD	10
18	MAINTENANCE BOND (24-MONTH)	L SUM	1

* = NOMINAL QUANTITY PROVIDED FOR ADJUSTMENTS DURING CONSTRUCTION

LEGEND

-  EXISTING LIGHT POLE AND LUMINAIRE
-  EXISTING MAST ARM AND LUMINAIRE MOUNTED ON UTILITY POLE
-  EXISTING MAST ARM AND LUMINAIRE TO BE REMOVED
-  LIGHT STANDARD, 25 FT. M.H., 10 FT. CLAMP-ON MAST ARM, LED LUMINAIRE ON LIGHT POLE FOUADATION, METAL
-  PROPOSED HANDHOLE
-  PROPOSED LIGHTING CONTROLLER
-  PROPOSED UNIT DUCT WITH 2-1/C No. 6 & 1-1/C No. 8 GROUND, 600V (XLP-TYPE USE), 1" DIA. OR AS NOTED
-  PROPOSED RIGID GALVANIZED STEEL CONDUIT

-  CONTROLLER IDENTIFICATION (TYP.)
-  CIRCUIT NUMBER (TYP.)
-  POLE NUMBER (TYP.)

GENEREAL NOTES, LEGEND, SUMMARY OF QUANTITIES

GREGORY STREET LIGHTING VILLAGE OF MOUNT PROSPECT




8725 W. Higgins Rd, Ste 600, Chicago, IL 60631
P 773.775.4009 | www.ciorba.com

USER NAME	= Personal	DESIGNED	- AM	REVISED	-
		DRAWN	- AM	REVISED	-
		CHECKED	- JMV	REVISED	-
PLOT DATE	= 7/2/2026	DATE	- 5/6/2026	REVISED	-


SCALE:	SHEET	OF	SHEETS	STA.	TO STA.
--------	-------	----	--------	------	---------

F.A. RTE.	SECTION	COUNTY	TOTAL SHEETS	SHEET NO.
		COOK	17	2
CONTRACT NO.				
		ILLINOIS	FED. AID PROJECT	


MODEL: Default
FILE NAME: c:\pwc\gl\pood\ms60407\0022007 01-Border-Plan.dgn

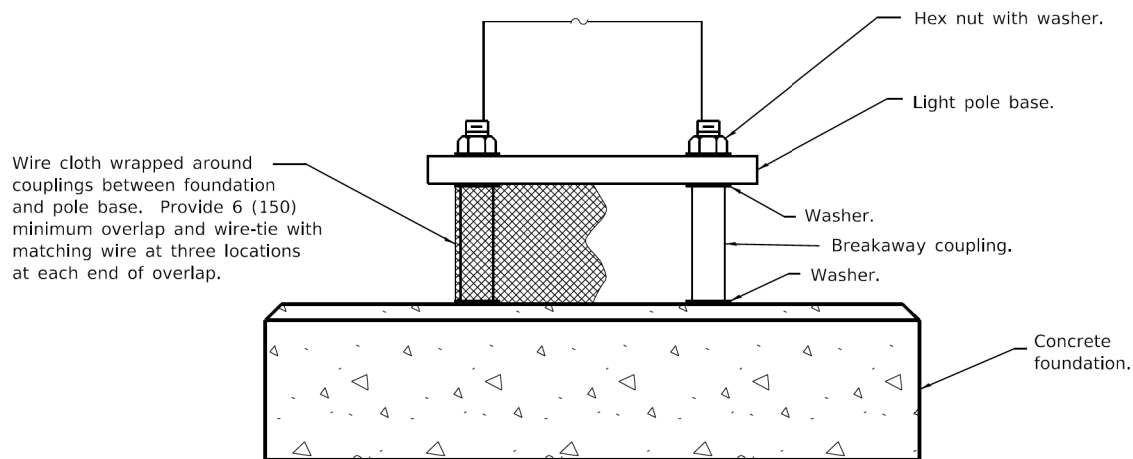

**BREAKAWAY COUPLINGS ON CONCRETE
FOUNDATION FOR STEEL LIGHT POLE**
(Provide pole base skirt around wire cloth when required.)

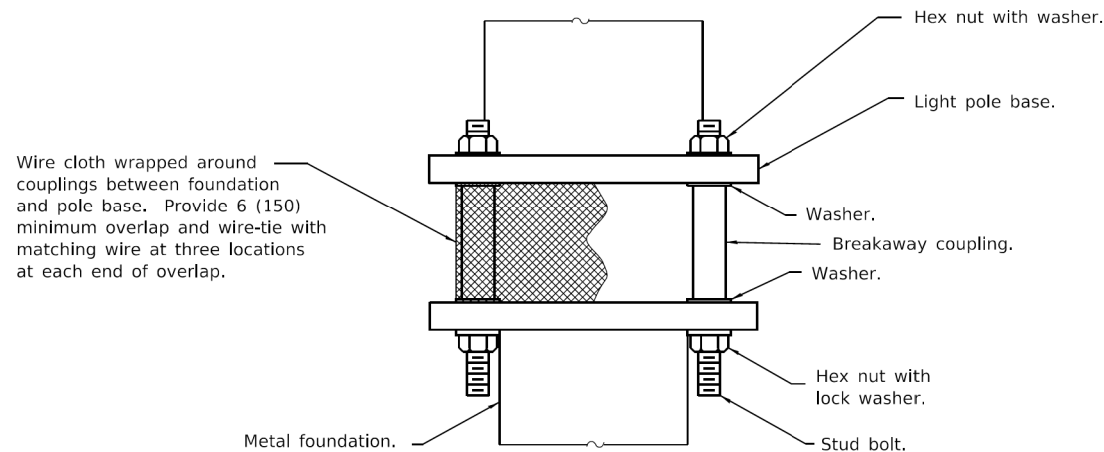

**BREAKAWAY COUPLINGS ON METAL
FOUNDATION FOR STEEL POLE**
(Provide pole base skirt around wire cloth when required.)

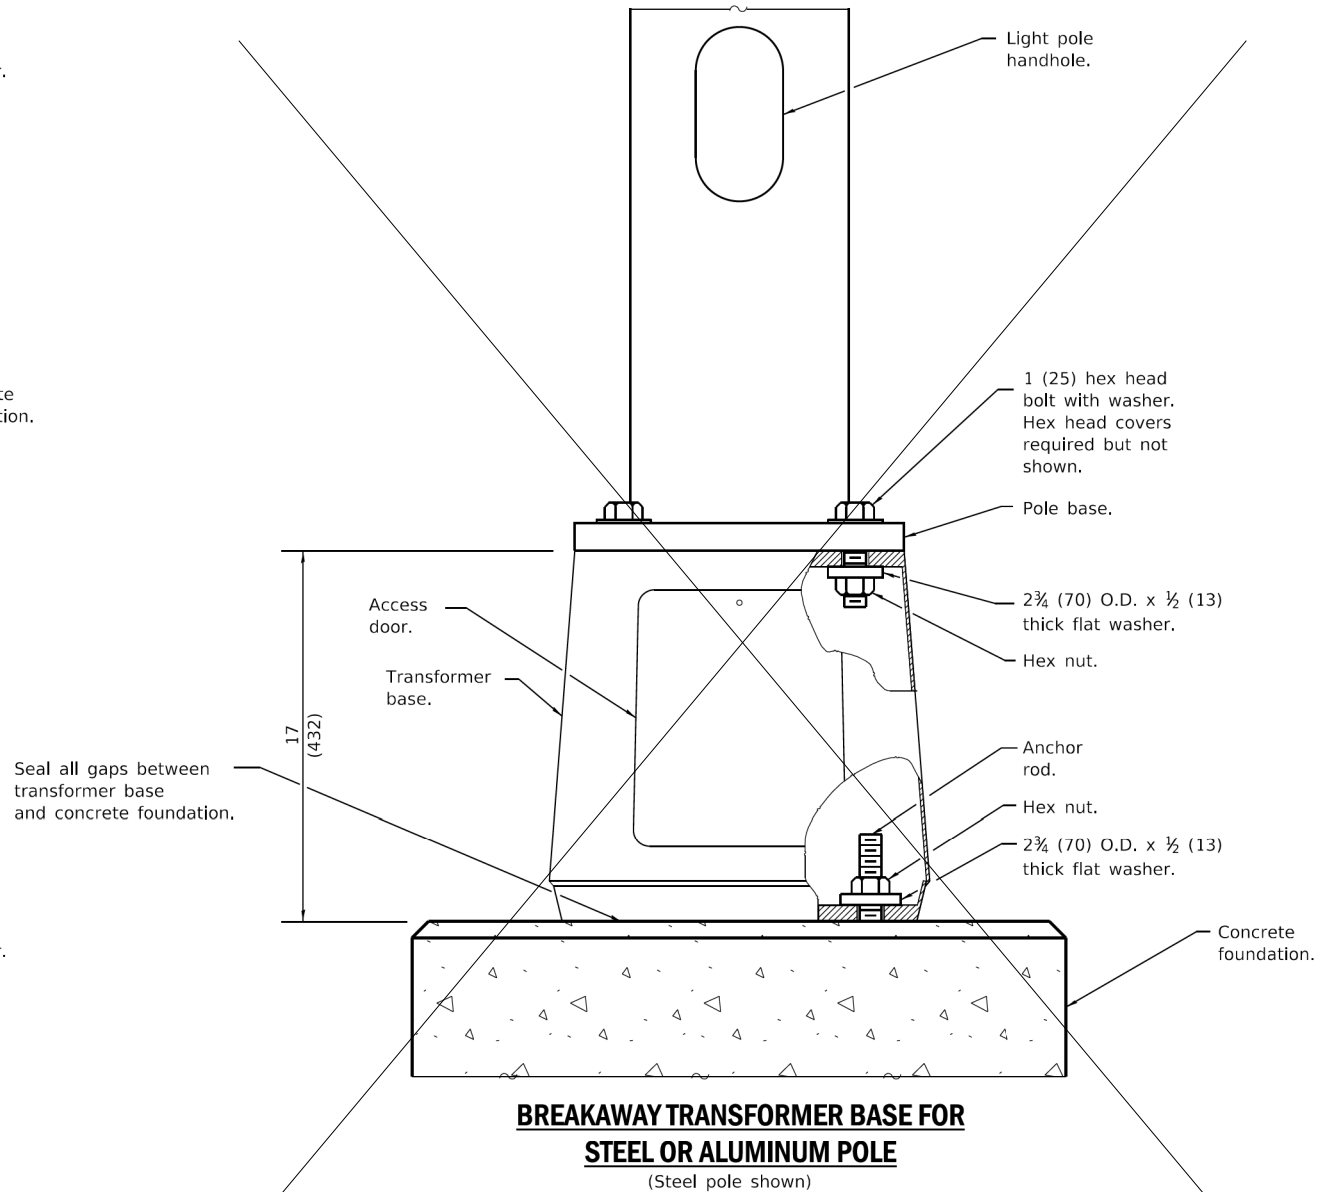

**BREAKAWAY TRANSFORMER BASE FOR
STEEL OR ALUMINUM POLE**
(Steel pole shown)

Illinois Department of Transportation	
PASSED January 1, 2018	ISSUED 1-1-12
ENGINEER OF PRELIMINARY ENGINEERING	
APPROVED January 1, 2018	
ENGINEER OF DESIGN AND ENVIRONMENT	

DATE		REVISIONS	BREAKAWAY DEVICES (Sheet 1 of 2) STANDARD 838001-01
1-1-18		Revised to show rodent shield installation for aluminum poles.	
1-1-14		New Standard.	

See Sheet 2 for GENERAL NOTES.

MODEL: Default
FILE NAME: c:\pwworking\ciorba\60407\0022007 01-Border-Plan.dgn

USER NAME = Personal	DESIGNED - AM	REVISED -
	DRAWN - AM	REVISED -
	CHECKED - JMV	REVISED -
PLOT DATE = 7/2/2026	DATE - 5/6/2026	REVISED -

F.A. RTE.	SECTION	COUNTY	TOTAL SHEETS	SHEET NO.
		COOK	17	3
CONTRACT NO.				
ILLINOIS FED. AID PROJECT				

 
MODEL: Default
FILE NAME: c:\pwworking\ciorba\dwg\60407\0022007 01-Border-Plan.dgn



Illinois Department of Transportation

PASSED


January 1, 2018



ENGINEER OF PRELIMINARY ENGINEERING


APPROVED

 January 1, 2018




ENGINEER OF DESIGN AND ENVIRONMENT


ISSUED 1-1-12

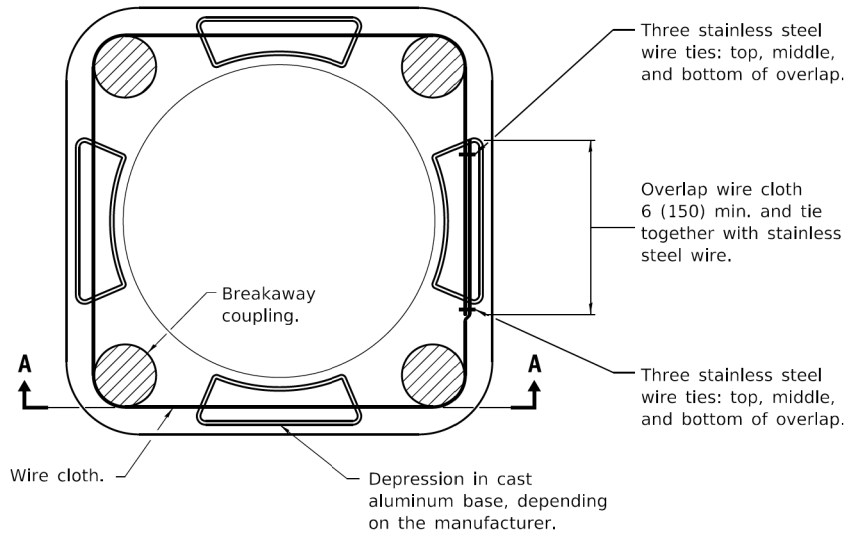

VIEW B-B

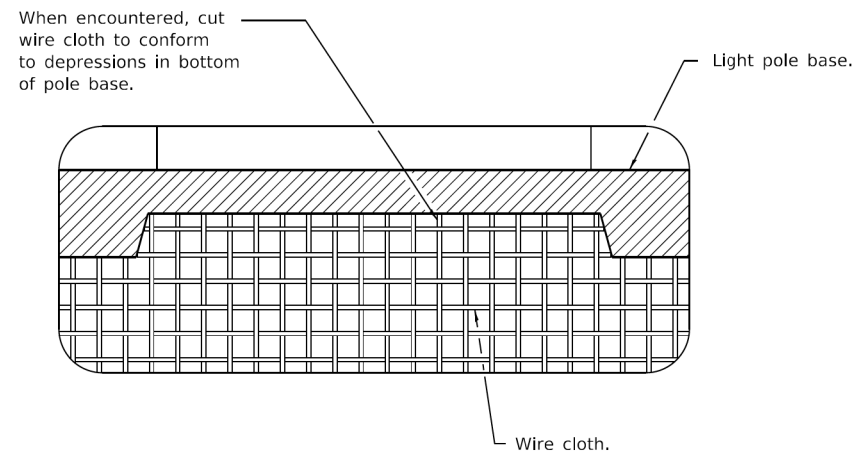

VIEW A-A

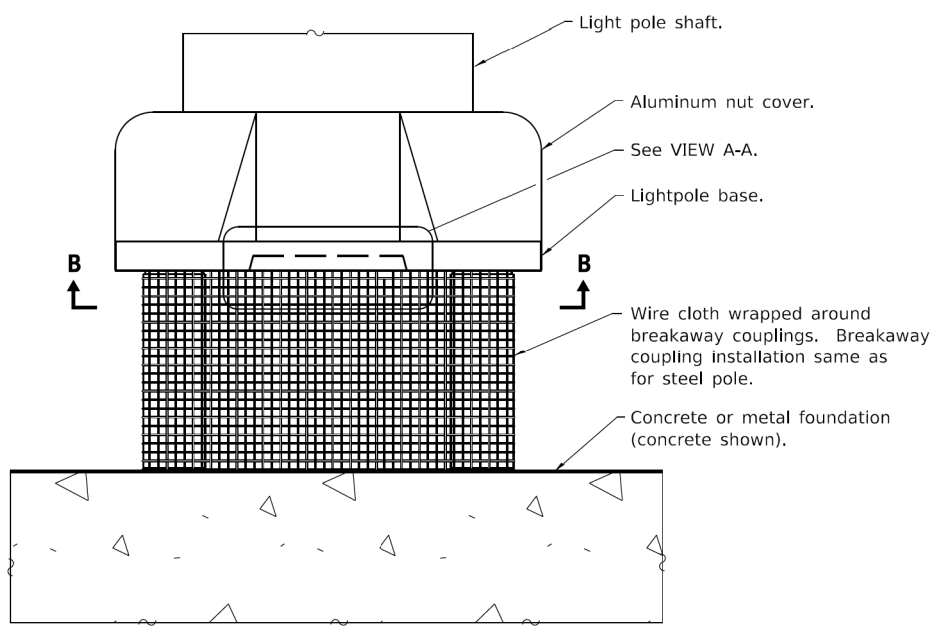

BREAKAWAY COUPLINGS FOR ALUMINUM POLES

(Provide pole base skirt around wire cloth when required.)

GENERAL NOTES

- See light pole standard for details not shown.
- Use largest transformer base bolt circle possible.
- Transformer bases shall not be installed on metal foundations.
- Washers on top of pole base shall cover the entire bolt slot.
- See Standard 836001 for Light Pole Foundation.
- Wire cloth shall be stainless steel, have a maximum opening of 1/4 (6), and have a minimum wire size of AWG No. 16 (1.6).
- All dimensions are in inches (millimeters) unless otherwise shown.

BREAKAWAY DEVICES

(Sheet 2 of 2)

STANDARD 838001-01



8725 W. Higgins Rd, Ste 600, Chicago, IL 60631
P 773.775.4009 | www.ciorba.com



USER NAME = Personal	DESIGNED - AM	REVISED -
	DRAWN - AM	REVISED -
	CHECKED - JMV	REVISED -
PLOT DATE = 7/2/2026	DATE - 5/6/2026	REVISED -

**GREGORY STREET LIGHTING
VILLAGE OF MOUNT PROSPECT**

LIGHTING DETAILS

SCALE: N.T.S. SHEET 2 OF 9 SHEETS STA. TO STA.

F.A. RTE.	SECTION	COUNTY	TOTAL SHEETS	SHEET NO.
		COOK	17	4
CONTRACT NO.				
ILLINOIS FED. AID PROJECT				

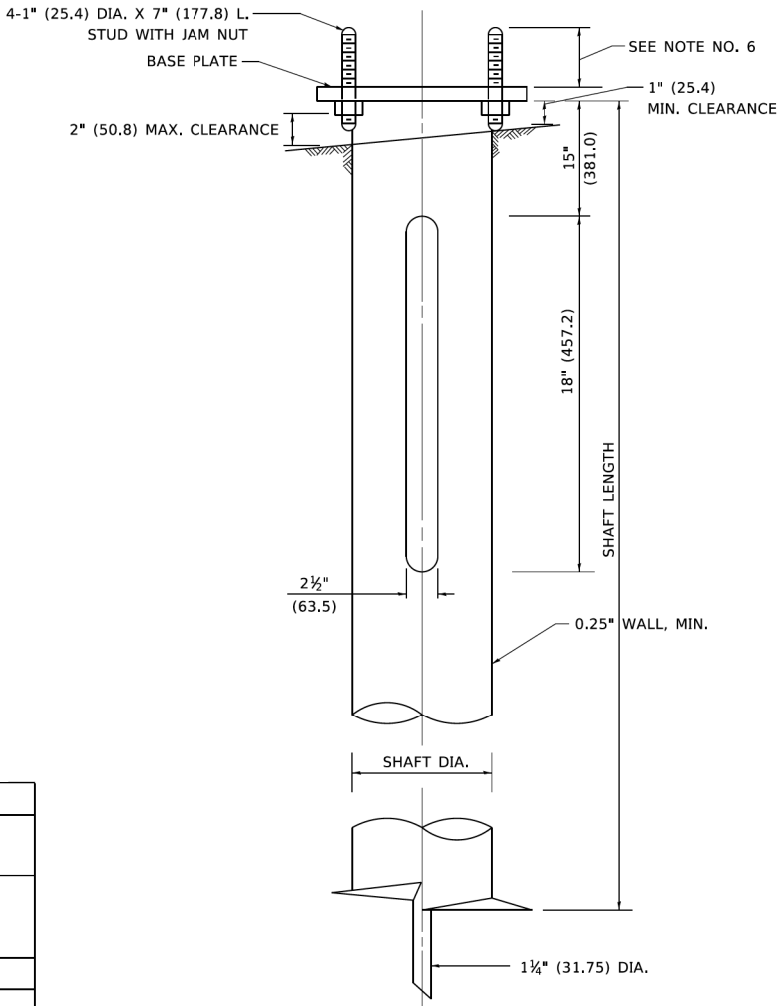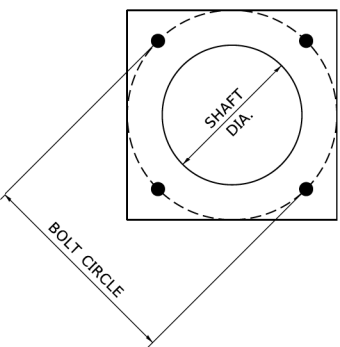

HELIX FOUNDATION SIZE

POLE MOUNTING HEIGHT	BOLT CIRCLE	SHAFT DIAMETER	SHAFT LENGTH	BASEPLATE
30 FT.	11 1/2"	8 3/8"	6 FT.	12"x12"x1"
31 FT.-35 FT.	11 1/2"	8 3/8"	6 FT.	12"x12"x1"
36 FT.-40FT.	15"	8 3/8"	6 FT.	15"x15"x1 1/4"
41 FT.-45 FT.	15"	8 3/8"	6 FT.	15"x15"x1 1/4"
46 FT.-50 FT.	15"	10"	8 FT.	15"x15"x1 1/4"

METAL HELIX FOUNDATION MATERIALS

ITEM	MATERIAL REQUIREMENT
BASEPLATE	AASHTO M 270M, GRADE 36 (M270M, GRADE 250)
SHAFT	ASTM A 252, GRADE 2 (PHOSPHOROUS 0.04% MAXIMUM, SULFUR 0.05% MAXIMUM)
HELIX SCREW	AASHTO M 183 (ASTM A 635)
PILOT POINT	AASHTO M 270 (ASTM A 575)
ANCHOR RODS/STUDS	AASHTO M 314 (ASTM F 1554)
HEXAGON NUTS	AASHTO M 291M (ASTM A 563) GRADE DH, OR AASHTO M 292 (ASTM A 194) GRADE 2H
WASHERS	AASHTO M 293 (ASTM F 436)

NOTES

- ALL DIMENSION IN INCHES (MILLIMETERS) UNLESS OTHERWISE SHOWN.
- ALL MATERIAL SHALL BE GALVINIZED ACCORDING TO AASHTO M111, UNLESS OTHERWISE SPECIFIED.
- ALL WELDS SHALL BE CONTINUOUS AND NOT LESS THAN 1#4" (6.35 mm) FILLET WELDS. THE WELDED FOUNDATION SHALL BE CAPABLE OF WITHSTANDING 10,000 FT/LBS (13558.18 n.m) OF INSTALLATION TORQUE APPLIED ABOUT THE AXIS OF THE FOUNDATION.
- THE HELIX FOUNDATION SHAFT SHALL BE INSTALLED VERTICAL AND THE BASE PLATE SHALL BE IN LEVEL. THE BREAKAWAY COUPLINGS AND HARDWARE SHALL NOT BE USED TO ALIGN THE POLE INSTALLATION.
- THE CABLE TRENCH SHALL BE BACKFILLED AND FIRMLY COMPACTED BEFORE THE INSTALLATION OF THE LIGHT POLE.
- THE CONTRACTOR SHALL COORDINATE EXTENSION OF ANCHOR BOLTS ABOVE TOP OF THE BASE PLATE WITH THE BREAKAWAY DEVICE MANUFACTURER'S REQUIREMENTS.
- ANY VOIDS WITHIN THE METAL FOUNDATION SHALL BE FILLED WITH FINE AGGREGATE.
- METAL FOUNDATIONS SHALL BE INSTALLED IN UNDISTURBED SOIL. PREDRILLING A PILOT HOLE AND/OR BACKFILLING AROUND THE FOUNDTION IS NOT ALLOWED.
- THE METAL FOUNDATION SHALL NOT BE INSTALLED TO A TORQUE WHICH EXCEEDS THE MANUFACTURER'S MAXIMUM TORQUE RATING NOR SHALL IT BE INSTALLED TO AN INSTALLATION TORQUE VALUE OF LESS THAN 3,500 FT LB (4,750 KNM). METAL FOUNDATIONS THAT ARE NOT INSTALLED TO FULL INSTALLATION DEPTH OR DO NOT ACHIEVE THE MINIMUM INSTALLATION TORQUE SHALL BE REMOVED AND REPLACED WITH A CONCRETE FOUNDATION AT NO ADDITIONAL COST.
- THE BASEPLATE SHALL BE PERPENDICULAR TO THE SHAFT AXIS ($\pm 1^\circ$) AND THE HOLE CENTERLINE SHALL BE CONCENTRIC (± 0.188) TO THE SHAFT AXIS.
- THE PILOT POINT AND SHAFT AXIS SHALL BE CONCENTRIC (± 0.125) AND IN LINE ($\pm 2^\circ$).
- THE BASEPLATE SHALL BE STAMPED WITH THE MANUFACTURERS NAME AND DATE OF MANUFACTURE.

	USER NAME = footemj	DESIGNED -	REVISED -	STATE OF ILLINOIS DEPARTMENT OF TRANSPORTATION	LIGHT POLE FOUNDATION, METAL				F.A. RTE.	SECTION	COUNTY	TOTAL SHEETS	SHEET NO.
		DRAWN - DLB	REVISED -										
	PLOT SCALE = 50.0000 ' / in.	CHECKED -	REVISED -		BE-305		CONTRACT NO.						
	PLOT DATE = 4/19/2019	DATE - 02-27-07	REVISED -		SCALE: NONE SHEET 1 OF 1 SHEETS STA. TO STA.						ILLINOIS FED. AID PROJECT		

MODEL: Default
FILE NAME: c:\pwworking\projects\60407\0022007 01-Border-Plan.dgn

MODEL: Default
FILE NAME: c:\pwworking\projects\60407\0022007 01-Border-Plan.dgn

USER NAME = Personal	DESIGNED - AM	REVISED -
	DRAWN - AM	REVISED -
	CHECKED - JMV	REVISED -
PLOT DATE = 7/2/2026	DATE - 5/6/2026	REVISED -


GREGORY STREET LIGHTING
VILLAGE OF MOUNT PROSPECT

LIGHTING DETAILS



SCALE: N.T.S. SHEET 4 OF 9 SHEETS STA. TO STA.

F.A. RTE.	SECTION	COUNTY	TOTAL SHEETS	SHEET NO.
		COOK	17	6
CONTRACT NO.				
ILLINOIS FED. AID PROJECT				


MODEL: Default
FILE NAME: c:\pwworking\projects\60407\0022007 01-Border-Plan.dgn
2011 Aug 4/19/2019 3:21:36 PM User:Gomez

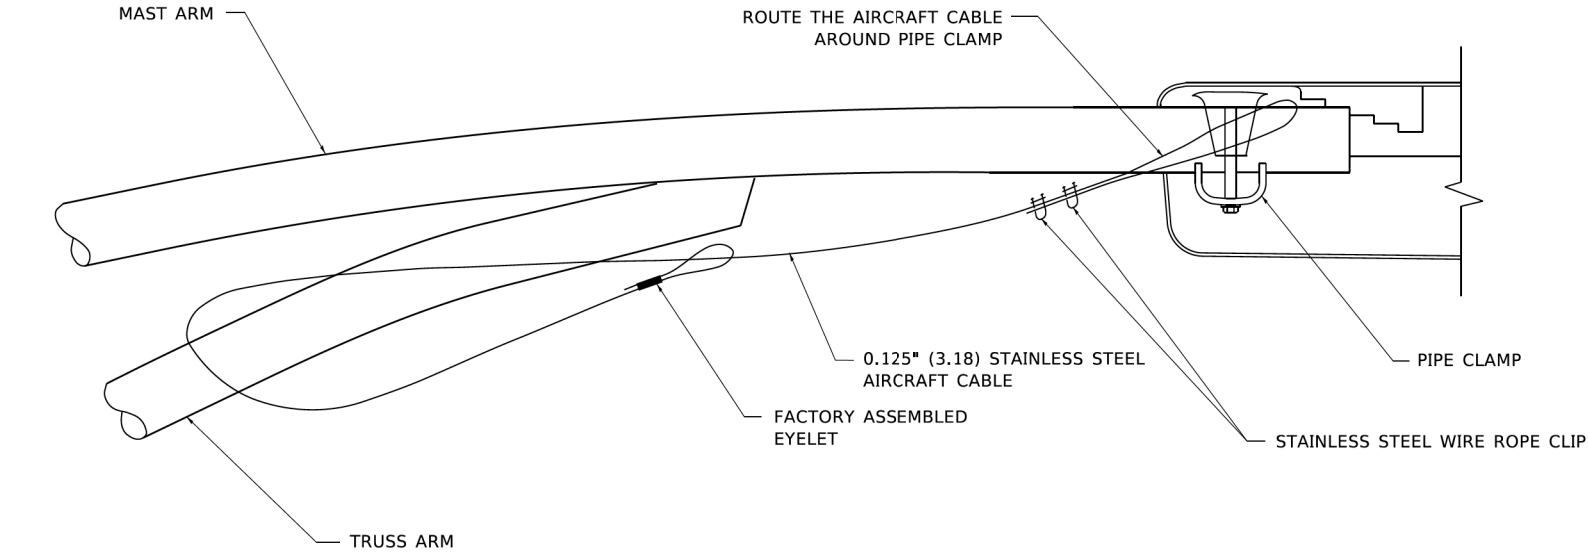

SIDE VIEW (TRUSS ARM)
N.T.S.

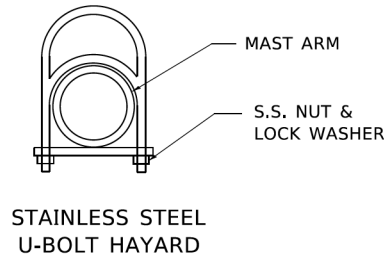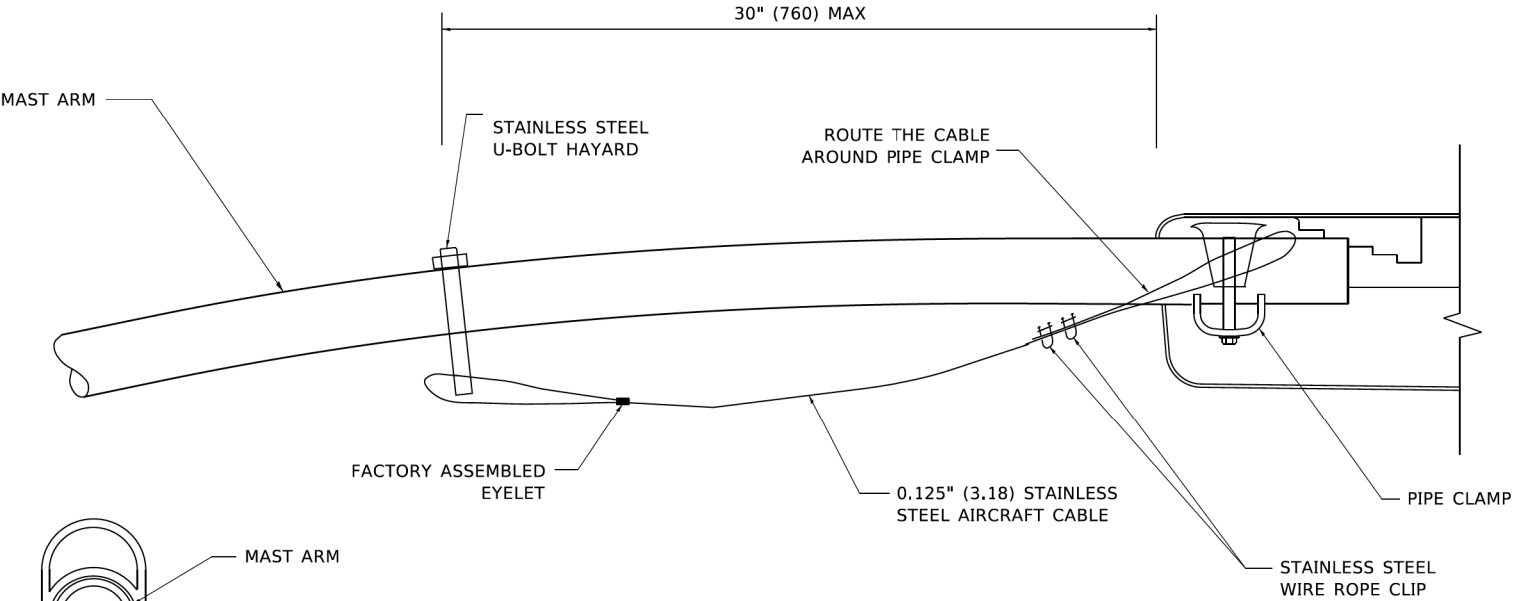

SIDE VIEW (SINGLE MEMBER OR DAVIT ARM)
N.T.S.

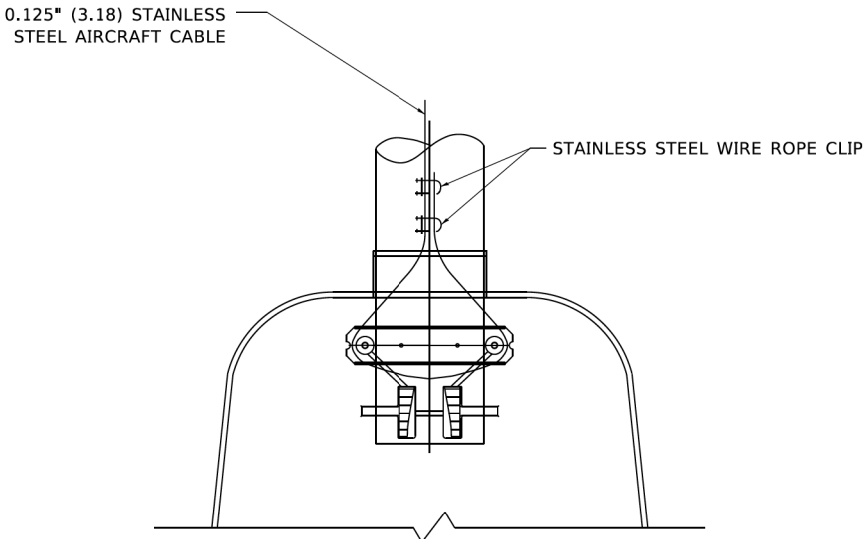

BOTTOM VIEW
N.T.S.

NOTES:

1. ALL DIMENSIONS ARE IN MILLIMETERS (INCHES) UNLESS OTHERWISE SHOWN.
2. CONTRACTOR SHALL ADJUST THE WIRE CLIP TO ELIMINATE ANY SLACK FROM THE WIRE ROPE.
3. THE 0.125\" (3.18) STAINLESS STEEL AIRCRAFT CABLE SHALL REMAIN VISIBLE FROM THE GROUND LEVEL.
4. THE BREAKING STRENGTH OF THE CABLE SHALL BE 1700 LBS. MIN.

	USER NAME = footemj	DESIGNED -	REVISED - 08-08-03	STATE OF ILLINOIS DEPARTMENT OF TRANSPORTATION	LUMINAIRE SAFETY CABLE ASSEMBLY	F.A. RTE.	SECTION	COUNTY	TOTAL SHEETS	SHEET NO.			
		DRAWN -	REVISED -										
	PLOT SCALE = 50.0000 ' / in.	CHECKED -	REVISED -			BE-701		CONTRACT NO.					
	PLOT DATE = 4/19/2019	DATE -	REVISED -			ILLINOIS FED. AID PROJECT							
	SCALE: NONE					SHEET 1 OF 1 SHEETS STA. TO STA.							

USER NAME = Personal	DESIGNED - AM	REVISED -
	DRAWN - AM	REVISED -
	CHECKED - JMV	REVISED -
PLOT DATE = 7/2/2026	DATE = 5/6/2026	REVISED -

LIGHTING DETAILS						F.A. RTE.	SECTION	COUNTY	TOTAL SHEETS	SHEET NO.
								COOK	17	7
						CONTRACT NO.				
SCALE: N.T.S.						SHEET 5 OF 9 SHEETS STA. TO STA.				
						ILLINOIS FED. AID PROJECT				



NOTES:

1. ALL CIRCUIT BREAKERS SHALL HAVE AN INTERRUPT RATING OF 18,000 AMPS
2. UL LISTED DEVICES/COMPONENTS SHALL BE USED
3. NO SPLICES OF WIRES IN CABINET
4. CONTROL WIRE TO BE #12 MTW
5. POWER WIRE SHALL BE RATED RHH/RHW 600 VOLTS OF SIZE INDICATED
6. LIGHTING CONTROLLER SHALL BE SERVICE ENTRANCE RATED
7. PANEL SHALL BE DEAD FRONT TO ALLOW OPERATION OF HOA SWITCH

LIGHTING CONTROLLER WIRING DIAGRAM

MODEL: Default
FILE NAME: c:\pwworkspace\hpc\604070022007.01-Border-Plan.dgn

10' ARM

RTA

Round Tapered Aluminum Pole with Arms
Single Truss — 4-Bolt Base

WARNING:
Do not install light pole without luminaire. *Satin Aluminum or Powder Coated Finish per Customer Specification.*

A	B	C	J	L	W	MAXIMUM EPA	OLD	CATALOG NUMBER
FEET	WALL THICKNESS	BUTT DIA.	ARM LENGTH	WEIGHT	90	100	110	
25	0.188"	8	10'	40	3.6	2.8	2.4	RTA25D8B4T1A-*

C	D	F	G	H	I
BUTT DIA.	TOP DIA.	BOLT CIRC. DIA.	BASE SQ.	BOLT PROJ.	BOLT SIZE
8	4.5	11 - 12	11.25	2.75	1 x 36 x 4

Dimensions in inches

CUSTOMER NAME:

PROJECT:

NOTES:

LOCATION:

QUANTITY:

EPA Notes: Effective Projected Area (EPA) in square feet. EPA's calculated using wind velocity (mph) indicated in accordance with 2009 ASHRAE 115-5 using a 25 year design life. Maximum EPA is based on the luminaire weight shown. Increased luminaire weight may reduce the maximum EPA. If weight is exceeded, or if other design life or code is required, please consult the factory.

hapco pole products
26252 Hillman Highway
Arlington, VA 24210
800.368.7171
www.hapco.com

12' ARM

RTA

Round Tapered Aluminum Pole with Arms
Single Truss — 4-Bolt Base

WARNING:
Do not install light pole without luminaire. *Satin Aluminum or Powder Coated Finish per Customer Specification.*

A	B	C	J	L	W	MAXIMUM EPA	OLD	CATALOG NUMBER
FEET	WALL THICKNESS	BUTT DIA.	ARM LENGTH	WEIGHT	90	100	110	
25	0.188"	8	12'	40	3.8	2.8	2.5	RTA25D8B4T1C-*

C	D	F	G	H	I
BUTT DIA.	TOP DIA.	BOLT CIRC. DIA.	BASE SQ.	BOLT PROJ.	BOLT SIZE
8	4.5	11 - 12	11.25	2.75	1 x 36 x 4

Dimensions in inches

CUSTOMER NAME:

PROJECT:

NOTES:

LOCATION:

QUANTITY:

EPA Notes: Effective Projected Area (EPA) in square feet. EPA's calculated using wind velocity (mph) indicated in accordance with 2009 ASHRAE 115-5 using a 25 year design life. Maximum EPA is based on the luminaire weight shown. Increased luminaire weight may reduce the maximum EPA. If weight is exceeded, or if other design life or code is required, please consult the factory.

hapco pole products
26252 Hillman Highway
Arlington, VA 24210
800.368.7171
www.hapco.com

15' ARM

RTA

Round Tapered Aluminum Pole with Arms
Single Truss — 4-Bolt Base

WARNING:
Do not install light pole without luminaire. *Satin Aluminum or Powder Coated Finish per Customer Specification.*

A	B	C	J	L	W	MAXIMUM EPA	OLD	CATALOG NUMBER
FEET	WALL THICKNESS	BUTT DIA.	ARM LENGTH	WEIGHT	90	100	110	
25	0.219"	8	15'	40	2.8	1.9	1.6	RTA25E8B4T1E-*

C	D	F	G	H	I
BUTT DIA.	TOP DIA.	BOLT CIRC. DIA.	BASE SQ.	BOLT PROJ.	BOLT SIZE
8	4.5	11 - 12	11.25	2.75	1 x 36 x 4

Dimensions in inches

CUSTOMER NAME:

PROJECT:

NOTES:

LOCATION:

QUANTITY:

EPA Notes: Effective Projected Area (EPA) in square feet. EPA's calculated using wind velocity (mph) indicated in accordance with 2009 ASHRAE 115-5 using a 25 year design life. Maximum EPA is based on the luminaire weight shown. Increased luminaire weight may reduce the maximum EPA. If weight is exceeded, or if other design life or code is required, please consult the factory.

hapco pole products
26252 Hillman Highway
Arlington, VA 24210
800.368.7171
www.hapco.com

USER NAME	= Personal	DESIGNED	- AM	REVISED	-
		DRAWN	- AM	REVISED	-
		CHECKED	- JMV	REVISED	-
PLOT DATE	= 7/2/2026	DATE	= 5/6/2026	REVISED	-

**GREGORY STREET LIGHTING
VILLAGE OF MOUNT PROSPECT**

LIGHTING DETAILS

SCALE: N.T.S. SHEET 7 OF 9 SHEETS STA. TO STA.


F.A. RTE.	SECTION	COUNTY	TOTAL SHEETS	SHEET NO.
		COOK	17	9
CONTRACT NO.				
ILLINOIS FED. AID PROJECT				



ComfortView™ Neighborhood LED Streetlight (CV)

Luminaire Data

Weight 8lbs [3.6kg]
EPA 0.39 ft²

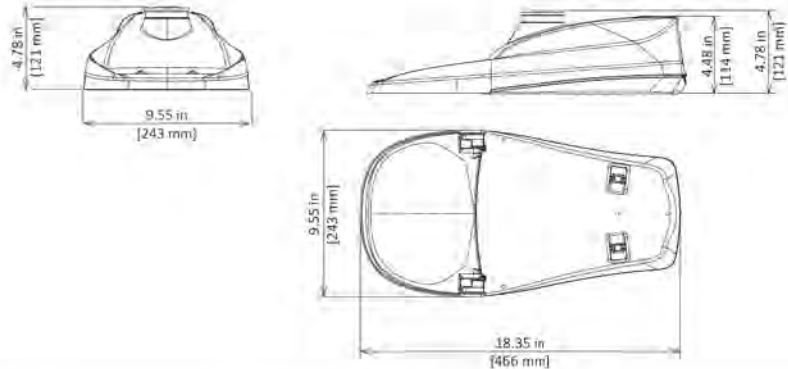

Ordering Information

Sample Catalog No. CV1-H-MV-40K-2R-GY-045-FOC

Product	LED Code	Voltage	Color Temperature	Distribution	Finish ¹	Output Code ²	Options
CV1	H	MV 120-277V	22K 2200K	2R Type 2	GY Gray	025	FOC ¹ Fixed Output Code
		HV 347-480V	27K 2700K	3R Type 3	DB Dark	030	LPCR Less Photocontrol
			30K 3000K		BK Black	035	Receptacle
			40K 4000K			040	PCR7 ⁴ ANSI 7-wire Photo-control Receptacle
						045	PCR7-CR ⁵ Control Ready 7-wire PC Receptacle
						055	WL Utility Wattage Label
						060	4B 4-Bolt Mounting Bracket
						070	RWG Rubber Wildlife Guard
						075	SWTB Straight Wire Terminal Block
						080	BBL Bubble Level
							CF ⁶ Coastal Paint Finish

Notes:

- Gray, Black, and Dark Bronze standard. Consult factory for other finishes.
- Specified output code is the factory set lumen performance. Field adjustable is standard via an eight-position output selector. Refer to output data table on this spec sheet. An illustration of the output selector and its label is shown on page 2. Consult factory if special output setting is required.
- Non-field adjustable, fixed lumen output. Specify required output code. Not available with PCR7-CR option.
- Includes output selector that enables field adjustability of light levels. Includes connectors to allow easy upgrade of wireless dimming via PCR7. Wireless node by others.
- Control-ready wired at factory for wireless node dimming (node by others). Output selector not included in the fixture. Not able to adjust above specified drive current.
- Specify the CF Option for coastal installation. See warranty for details.
- Flush mounted Cul-de-Sac Shield cuts light off at 1 times the mounting height behind the luminaire, 1% in front, and 2% times the mounting height laterally.
- Flush mounted Front Side Shield cuts light off at approximately 1% times the mounting height in front of the luminaire (street side) and 2% times the mounting height laterally.
- Flush mounted House Side Shield cuts light off at 1 times the mounting height behind the luminaire and 2% times the mounting height laterally.
- 80 Degree Cutoff Shield mitigates high angle glare above 80 degrees from nadir and cuts light off at 1% times the mounting height behind and 2% times the mounting height laterally.
- Specify Color (GY, DB, BK)
- Specify MV (120-277V) or HV (347-480V).

Accessories*

CSSCV ⁷	Cul-De-Sac Side Shield, Snap-On*
FSSCV ⁸	Front Side Shield, Snap-On*
HSSCV ⁹	House Side Shield, Snap-On*
VHCS ¹⁰	80 Degree Cutoff Shield, Grey*
PTB ¹¹	Pole Top Tenon Horizontal Arm Bracket
PTB2 ¹¹	Pole Top Tenon Horizontal Arm Bracket (2@180°)
RPB ¹¹	Round Pole Horizontal Arm Bracket
SPB ¹¹	Square Pole Horizontal Arm Bracket
WB ¹¹	Wall Horizontal Arm Bracket
LLPC ¹²	Long-Life Twist Lock Photocontrol
SC	Twist Lock Shorting Cap
BSK	Bird Deterrent Spider Kit

*Accessories are ordered separately and not to be included in the catalog number. For factory installed HSSCV, CSSCV, FSSCV and VHCS specify as option in luminaire catalog number. HSSCV, CSSCV, FSSCV can be installed without a tool, but a tool is required for removal. 80 Degree Cutoff Shield (VHCS) requires a Phillips head screwdriver for installation.



©2024 LEOTEK Electronics USA. Specifications subject to change without notice. ComfortView_Series_Specification Sheet_2-7-2024.
* 2700K and 3000K ComfortView fixtures are certified as Community Friendly Lighting Equipment by the Smart Outdoor Lighting Alliance (SOLA).



ComfortView™ Neighborhood LED Streetlight (CV)

Performance Data¹

All data nominal. IES files for all CCTs available at leotek.com.

Product	Color Temperature (CCT)	Output Code	Dial Selection	System Wattage (W)	Delivered Lumens (Lm) ²	Efficacy (Lm/W)	Field Adjustable Output Range
CV1-H	2200 (22K)	020	1	19	2087	110	
		025	2	24	2693	112	
		030	3	29	3224	111	
		040	4	34	3876	114	
		043	5	38	4222	111	
		045	6	43	4653	108	
		050	7	48	5101	106	
		065	8	66	6722	102	
	2700K (27K)	025	1	19	2242	118	Midblock
		030	2	24	2892	120	
		035	3	29	3463	119	
		040	4	34	4163	122	
		045	5	38	4535	119	
		050	6	43	4998	116	
		055	7	48	5479	114	
		070	8	66	7220	110	
	3000K (30K)	025	1	19	2412	127	Intersection
		030	2	24	3073	128	
		035	3	29	3676	127	
		045	4	35	4423	128	
		050	5	38	4777	126	
		055	6	45	5561	124	
		060	7	49	5800	118	
		075	8	67	7722	115	
	4000K (40K)	025	1	19	2675	139	
		035	2	24	3294	137	
		040	3	29	3930	136	
		045	4	34	4561	134	
		050	5	38	5059	133	
		055	6	43	5594	130	
		060	7	48	6147	128	
		080	8	67	8227	123	

Notes:

- Data shown above is for type 2 optic. For type 3 optic, consult IES files for specific data at Leotek.com
- Nominal lumens. Normal tolerance ± 10% due to factors including LED bin variance, and ambient temperatures.

©2024 LEOTEK Electronics USA. Specifications subject to change without notice. ComfortView_Series_Specification Sheet_2-7-2024.

MODEL: Default
FILE NAME: c:\pwworking\leotek\604070022007 01-Border-Plan.dgn




USER NAME = Personal	DESIGNED - AM	REVISED -
	DRAWN - AM	REVISED -
	CHECKED - JMV	REVISED -
PLOT DATE = 7/2/2026	DATE - 5/6/2026	REVISED -

GREGORY STREET LIGHTING
VILLAGE OF MOUNT PROSPECT


LIGHTING DETAILS

SCALE: N.T.S. SHEET 8 OF 9 SHEETS STA. TO STA.


F.A. RTE.	SECTION	COUNTY	TOTAL SHEETS	SHEET NO.
		COOK	17	10
CONTRACT NO.				
ILLINOIS FED. AID PROJECT				

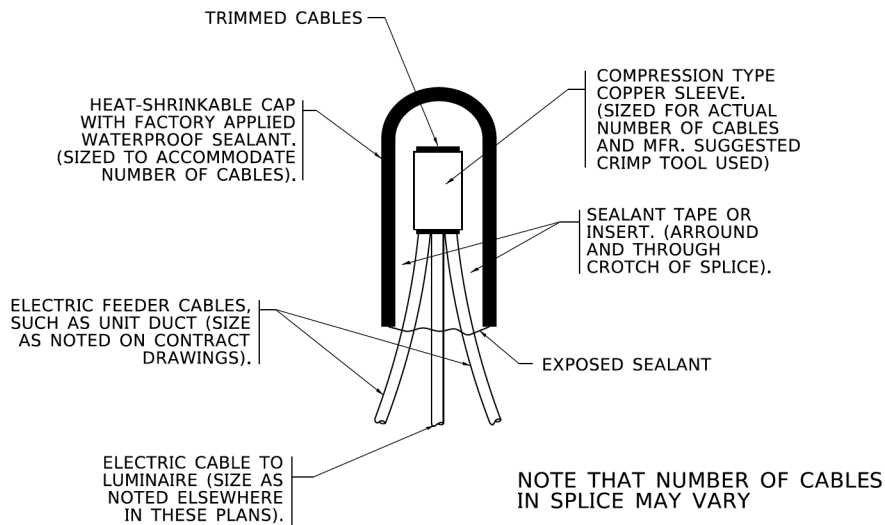

TYPICAL SPLICE DETAIL
N.T.S.

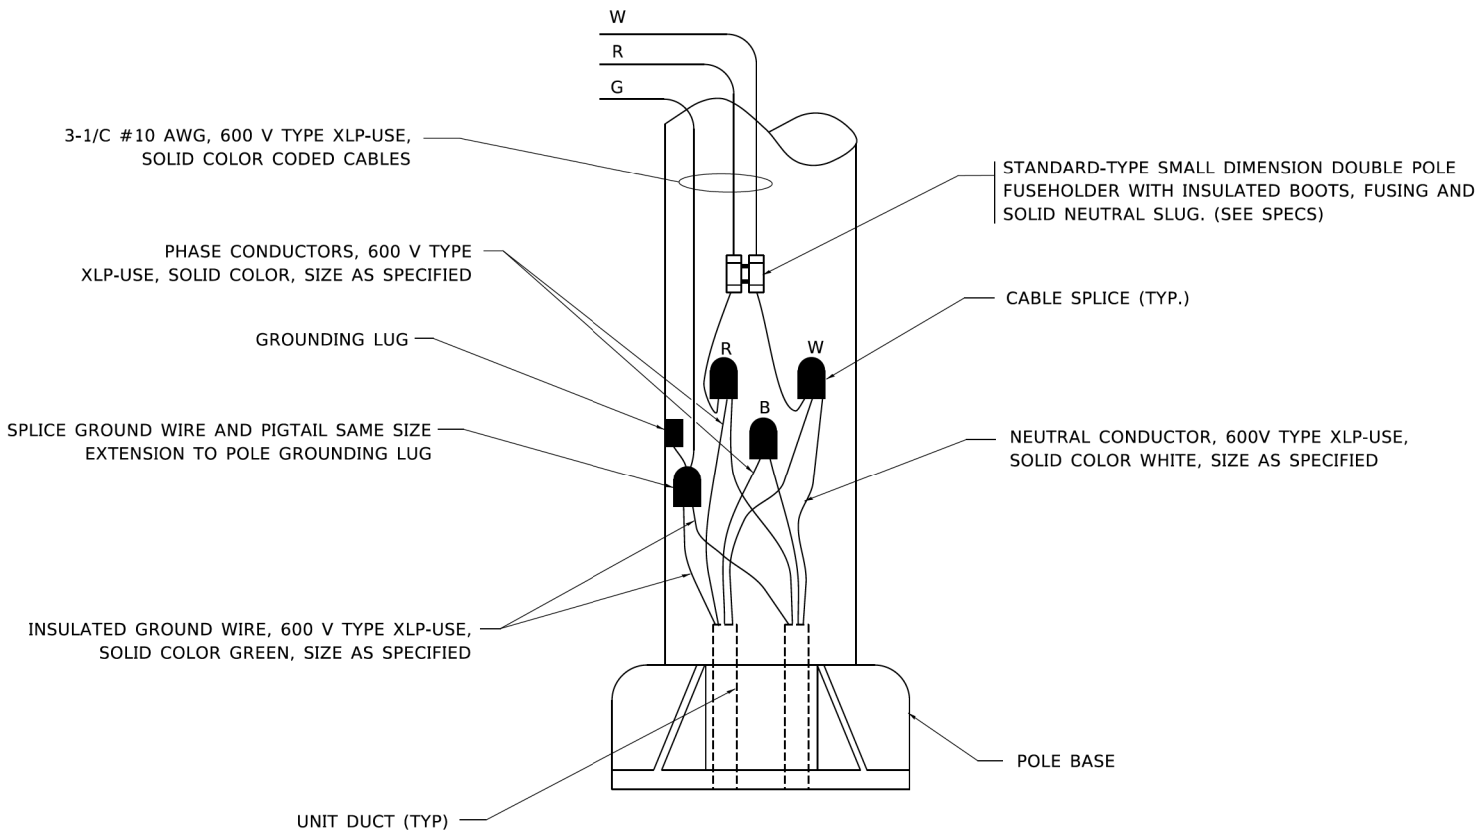

POLE WIRING DETAIL
N.T.S.

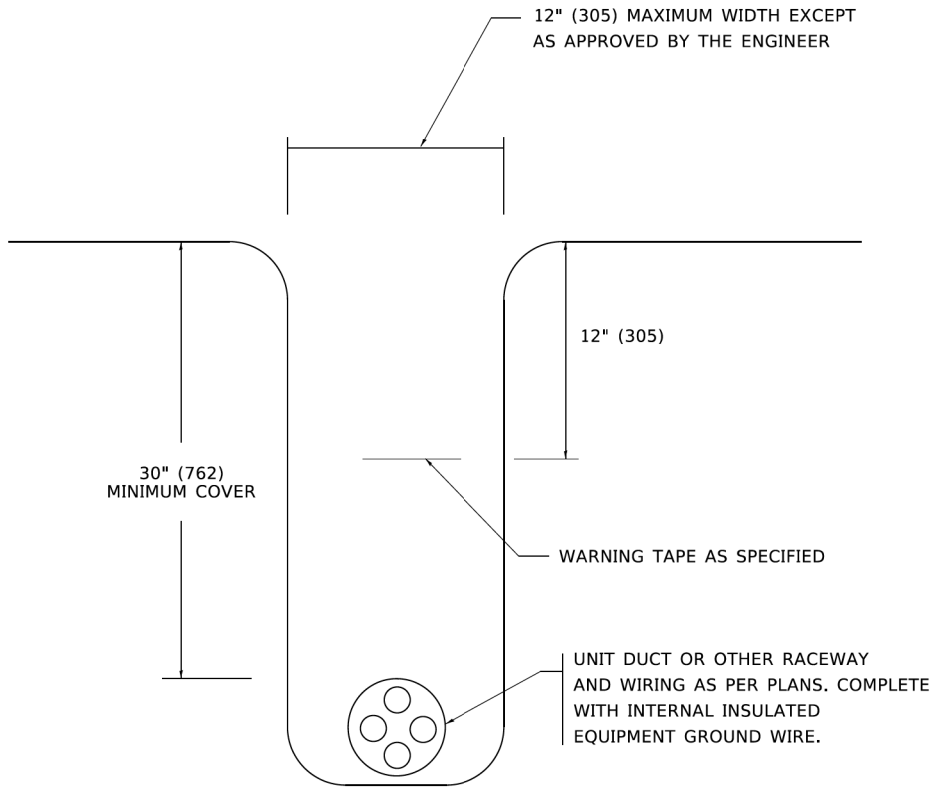

TYPICAL WIRING IN TRENCH DETAIL
N.T.S.

MODEL: Default
FILE NAME: c:\pwworking\projects\60407\0022007 01-Border-Plan.dgn

USER NAME = lleya	DESIGNED -	REVISED - 02/04/2020
	DRAWN -	REVISED -
PLOT SCALE = 50.0000 ' / in.	CHECKED -	REVISED -
PLOT DATE = 3/2/2020	DATE - 08/08/2003	REVISED -

STATE OF ILLINOIS
DEPARTMENT OF TRANSPORTATION

MISC. ELECTRICAL DETAILS					F.A. RTE.	SECTION	COUNTY	TOTAL SHEETS	SHEET NO.
SHEET A									
					BE-702			CONTRACT NO.	
SCALE: NONE	SHEET 1	OF 1	SHEETS	STA.	TO STA.				
					ILLINOIS FED. AID PROJECT				


MODEL: Default
FILE NAME: c:\pwworking\projects\60407\0022007 01-Border-Plan.dgn

CiorbaGroup
8725 W. Higgins Rd, Ste 600, Chicago, IL 60631
P 773.775.4009 | www.ciorba.com

USER NAME = Personal	DESIGNED - AM	REVISED -
	DRAWN - AM	REVISED -
	CHECKED - JMV	REVISED -
PLOT DATE = 7/2/2026	DATE - 5/6/2026	REVISED -


GREGORY STREET LIGHTING
VILLAGE OF MOUNT PROSPECT

LIGHTING DETAILS				F.A. RTE.	SECTION	COUNTY	TOTAL SHEETS	SHEET NO.
SCALE: N.T.S.								
SHEET 9 OF 9 SHEETS				STA.		TO STA.		
						COOK	17	II
				CONTRACT NO.				
				ILLINOIS FED. AID PROJECT				

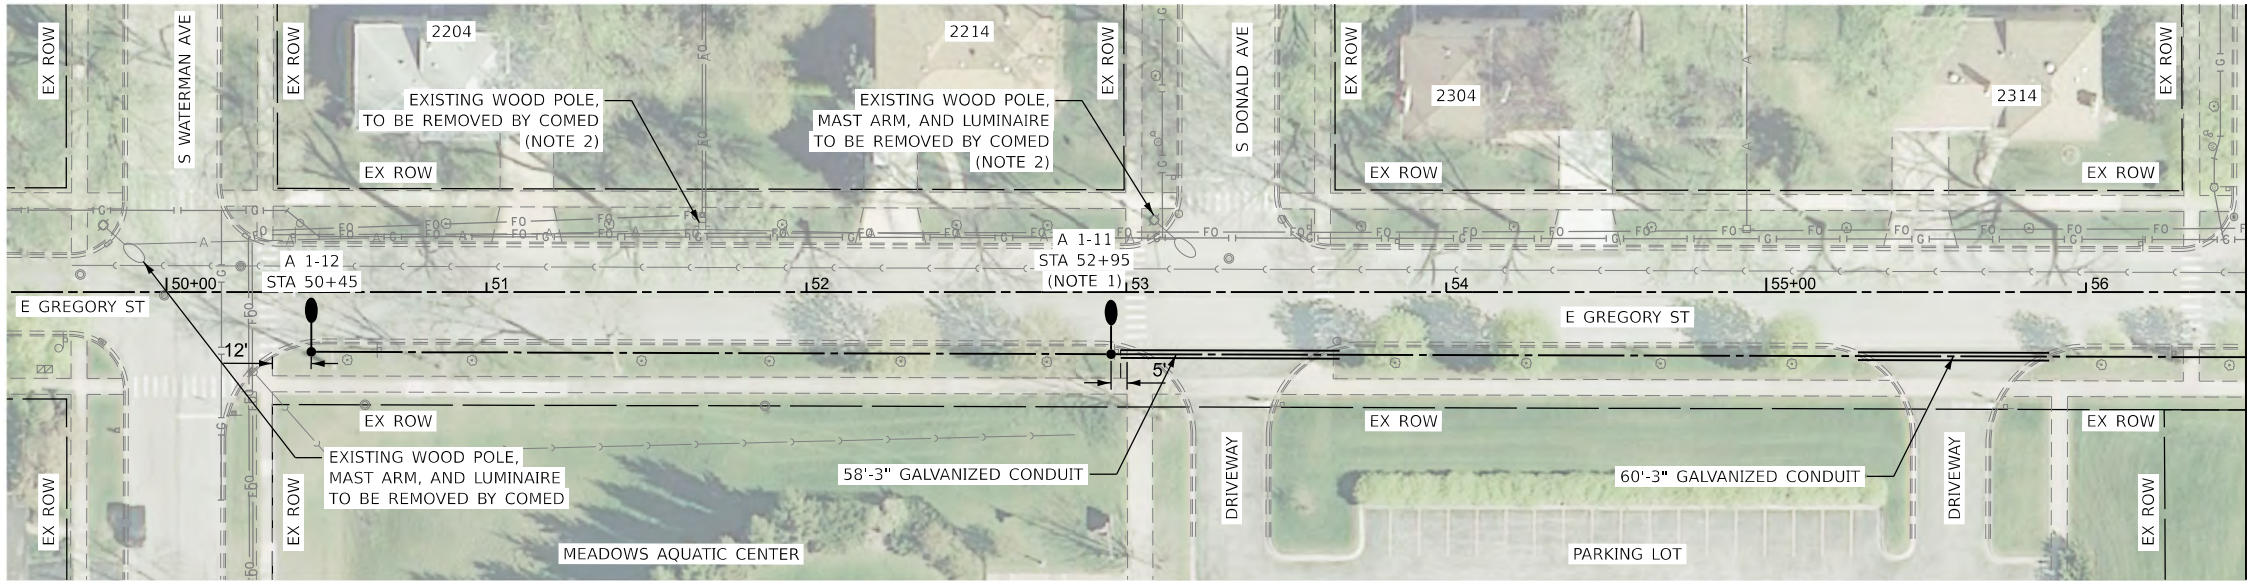


LEGEND

- EXISTING LIGHT POLE AND LUMINAIRE
- EXISTING MAST ARM AND LUMINAIRE MOUNTED ON UTILITY POLE
- EXISTING MAST ARM AND LUMINAIRE TO BE REMOVED
- LIGHT STANDARD, 25 FT. M.H., 10 FT. UNLESS NOTED OTHERWISE. CLAMP-ON MAST ARM, LED LUMINAIRE ON LIGHT POLE FOUNDATION, METAL
- PROPOSED HANDHOLE
- PROPOSED LIGHTING CONTROLLER
- PROPOSED UNIT DUCT WITH 2-1/C No. 6 & 1-1/C No. 8 GROUND, 600V (XLP-TYPE USE), 1" DIA. OR AS NOTED
- PROPOSED RIGID GALVANIZED STEEL CONDUIT
- CONTROLLER IDENTIFICATION (TYP.)
- CIRCUIT NUMBER (TYP.)
- POLE NUMBER (TYP.)

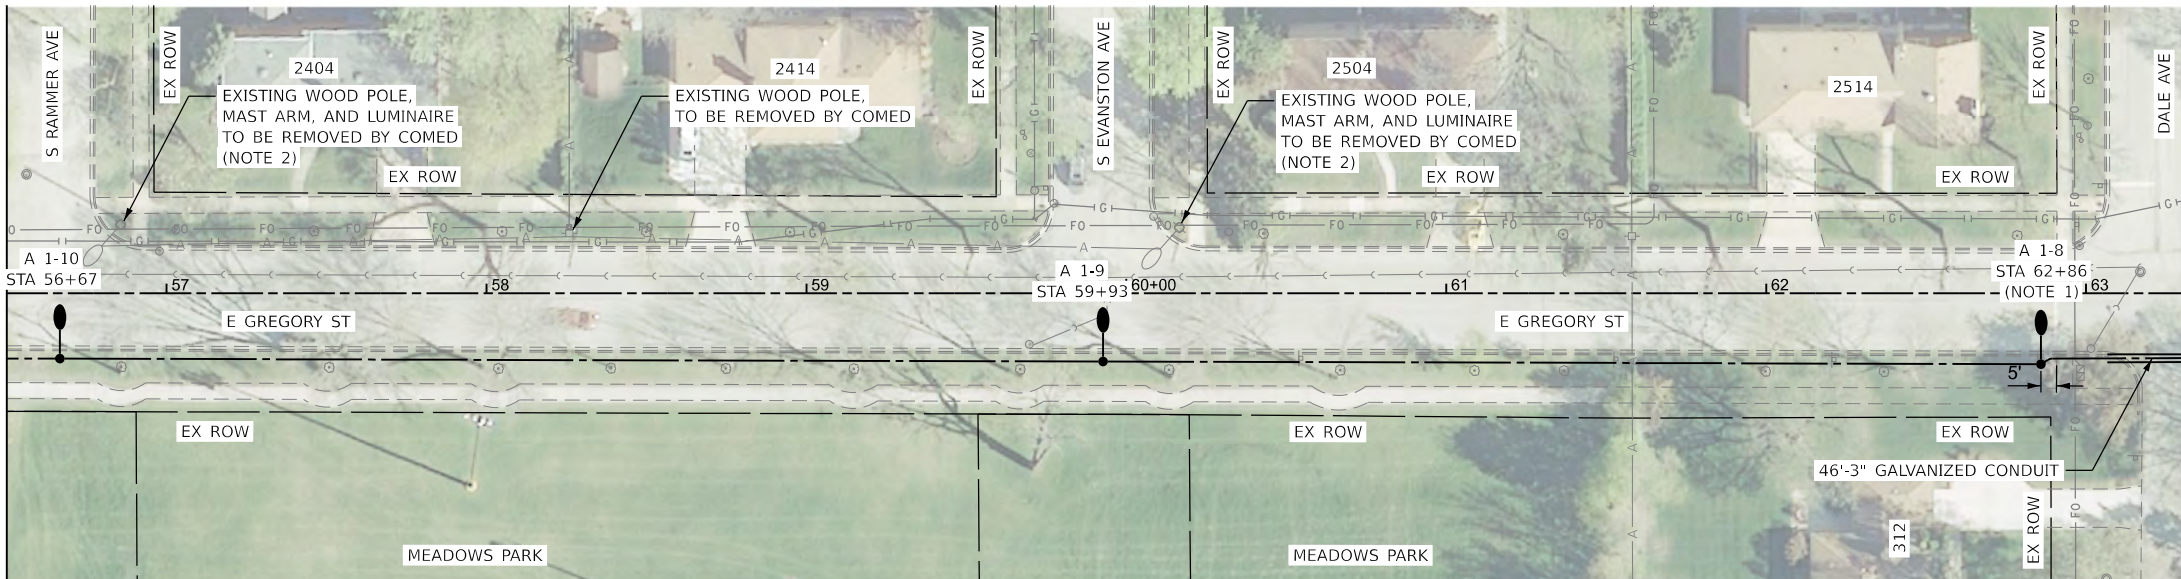

NOTES

 - VILLAGE TO RELOCATE EXISTING STREET SIGNS FROM SIGN POSTS TO PROPOSED LIGHT POLES.
- VILLAGE TO RELOCATE EXISTING STREET SIGNS FROM EXISTING WOOD LIGHT POLES TO SIGN POSTS.
- OFFSET LIGHTING UNITS NEAR DRIVEWAYS TO MAINTAIN 6 FEET FROM EDGE OF DRIVEWAY TO EDGE OF FOUNDATION UNLESS NOTED OTHERWISE.
- LIGHTING UNIT SETBACK SHALL BE 3 FEET FROM FACE OF CURB TO CENTER OF FOUNDATION UNLESS NOTED OTHERWISE.
- LUMINAIRES AT MID-BLOCK LOCATIONS SHALL HAVE OUTPUT CODE 050 AND LUMINAIRES AT INTERSECTIONS SHALL HAVE OUTPUT CODE 070.
- WATERMAIN LOCATION SHALL BE VERIFIED IN THE FIELD PRIOR TO CONSTRUCTION.
- POLE MOUNTED PHOTOCCELL, 3-1/C #10 CABLE AND 1" DUCT INCLUDED IN THE COST OF LIGHTING CONTROLLER.



MODEL: Gregory - LTC201 [Sheet]
FILE NAME: c:\p\w-c\g\procd\0105049\022144.01-sjh-LTG.dgn




USER NAME = amarotta	DESIGNED - AM	REVISED -
	DRAWN - AM	REVISED -
	CHECKED - JMV	REVISED -
	DATE - 5/6/2026	REVISED -
PLOT DATE = 6/12/2026		

GREGORY STREET LIGHTING VILLAGE OF MOUNT PROSPECT

GREGORY ST PROPOSED LIGHTING PLAN


SCALE: 1"=30' SHEET 1 OF 4 SHEETS STA. 49+50.00 TO STA. 63+50.00

F.A. RTE.	SECTION	COUNTY	TOTAL SHEETS	SHEET NO.
		COOK	17	12
CONTRACT NO.				
ILLINOIS FED. AID PROJECT				

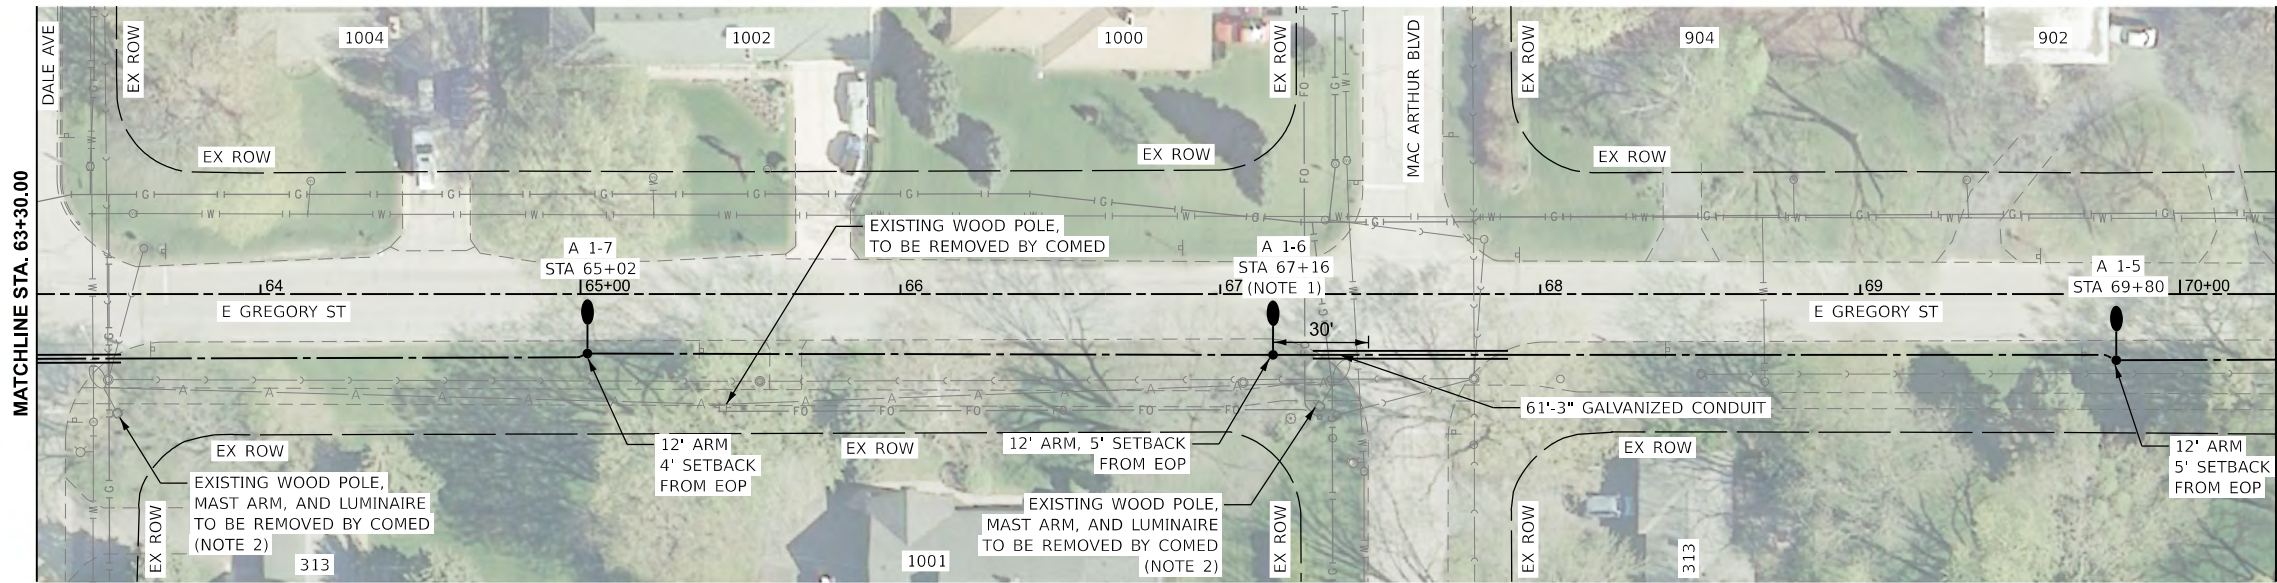


LEGEND

- EXISTING LIGHT POLE AND LUMINAIRE
- EXISTING MAST ARM AND LUMINAIRE MOUNTED ON UTILITY POLE
- EXISTING MAST ARM AND LUMINAIRE TO BE REMOVED
- LIGHT STANDARD, 25 FT. M.H., 10 FT. UNLESS NOTED OTHERWISE. CLAMP-ON MAST ARM, LED LUMINAIRE ON LIGHT POLE FOUNDATION, METAL
- PROPOSED HANDHOLE
- PROPOSED LIGHTING CONTROLLER
- PROPOSED UNIT DUCT WITH 2-1/C No. 6 & 1-1/C No. 8 GROUND, 600V (XLP-TYPE USE), 1" DIA. OR AS NOTED
- PROPOSED RIGID GALVANIZED STEEL CONDUIT
- CONTROLLER IDENTIFICATION (TYP.)
- CIRCUIT NUMBER (TYP.)
- POLE NUMBER (TYP.)

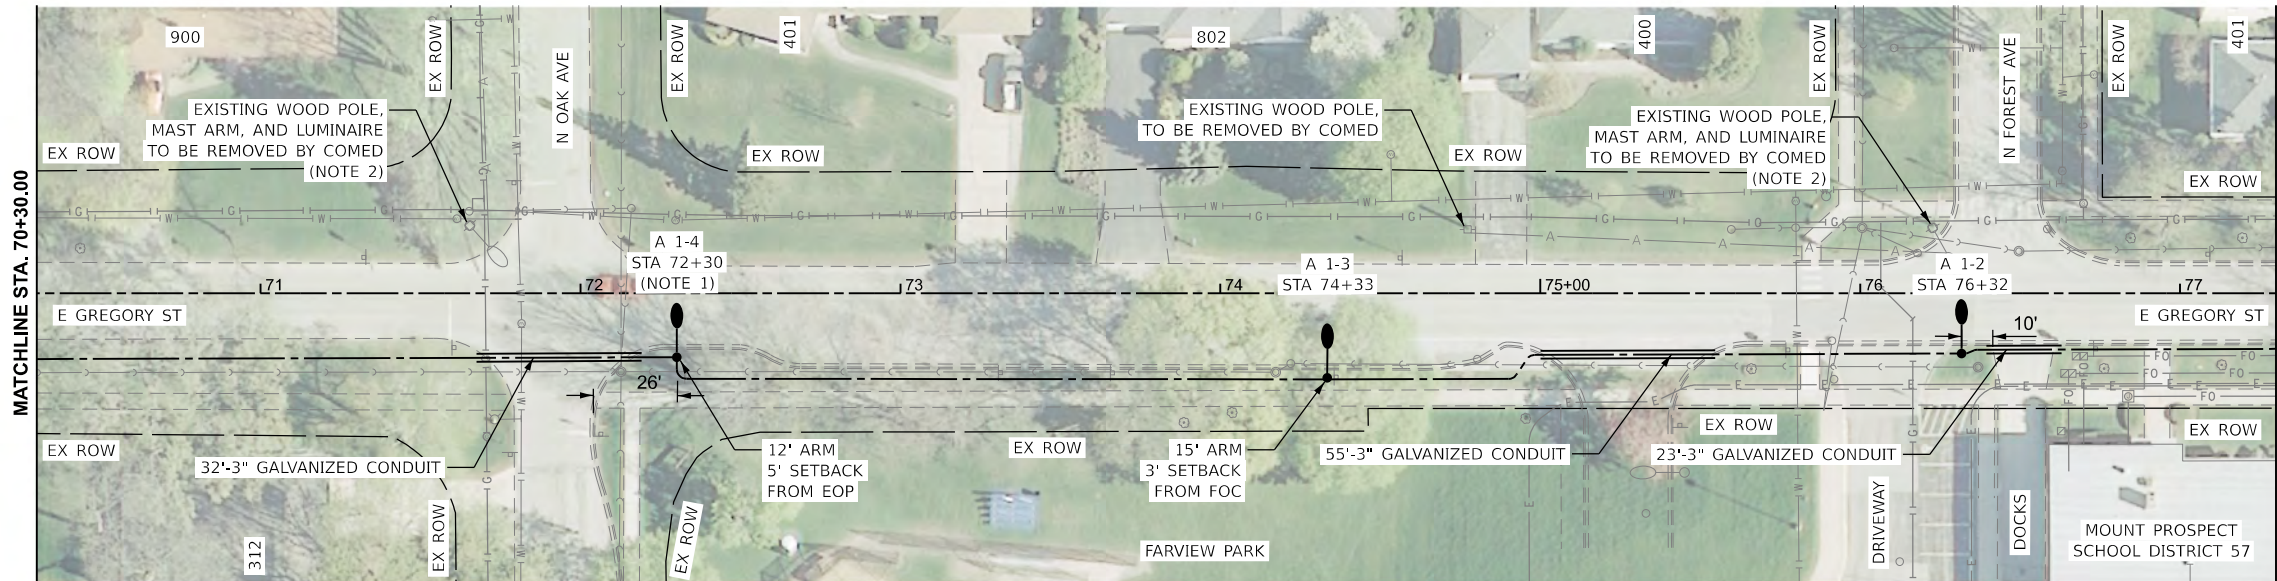

NOTES

 - VILLAGE TO RELOCATE EXISTING STREET SIGNS FROM SIGN POSTS TO PROPOSED LIGHT POLES.
- VILLAGE TO RELOCATE EXISTING STREET SIGNS FROM EXISTING WOOD LIGHT POLES TO SIGN POSTS.
- OFFSET LIGHTING UNITS NEAR DRIVEWAYS TO MAINTAIN 6 FEET FROM EDGE OF DRIVEWAY TO EDGE OF FOUNDATION UNLESS NOTED OTHERWISE.
- LIGHTING UNIT SETBACK SHALL BE 3 FEET FROM FACE OF CURB TO CENTER OF FOUNDATION UNLESS NOTED OTHERWISE.
- LUMINAIRES AT MID-BLOCK LOCATIONS SHALL HAVE OUTPUT CODE 050 AND LUMINAIRES AT INTERSECTIONS SHALL HAVE OUTPUT CODE 070.
- WATERMAIN LOCATION SHALL BE VERIFIED IN THE FIELD PRIOR TO CONSTRUCTION.
- POLE MOUNTED PHOTOCCELL, 3-1/C #10 CABLE AND 1" DUCT INCLUDED IN THE COST OF LIGHTING CONTROLLER.



MODEL: Gregory - LTC202 [Sheet]
FILE NAME: c:\p\w-cgi\prod\0105049\022144.01-sjh-LTG.dgn




USER NAME = amarotta	DESIGNED - AM	REVISED -
	DRAWN - AM	REVISED -
	CHECKED - JMV	REVISED -
	DATE - 5/6/2026	REVISED -
PLOT DATE = 7/2/2026		

GREGORY STREET LIGHTING VILLAGE OF MOUNT PROSPECT

GREGORY ST PROPOSED LIGHTING PLAN


SCALE: 1"=30' SHEET 2 OF 4 SHEETS STA. 63+50.00 TO STA. 77+50.00

F.A. RTE.	SECTION	COUNTY	TOTAL SHEETS	SHEET NO.
		COOK	17	13
CONTRACT NO.				
ILLINOIS FED. AID PROJECT				

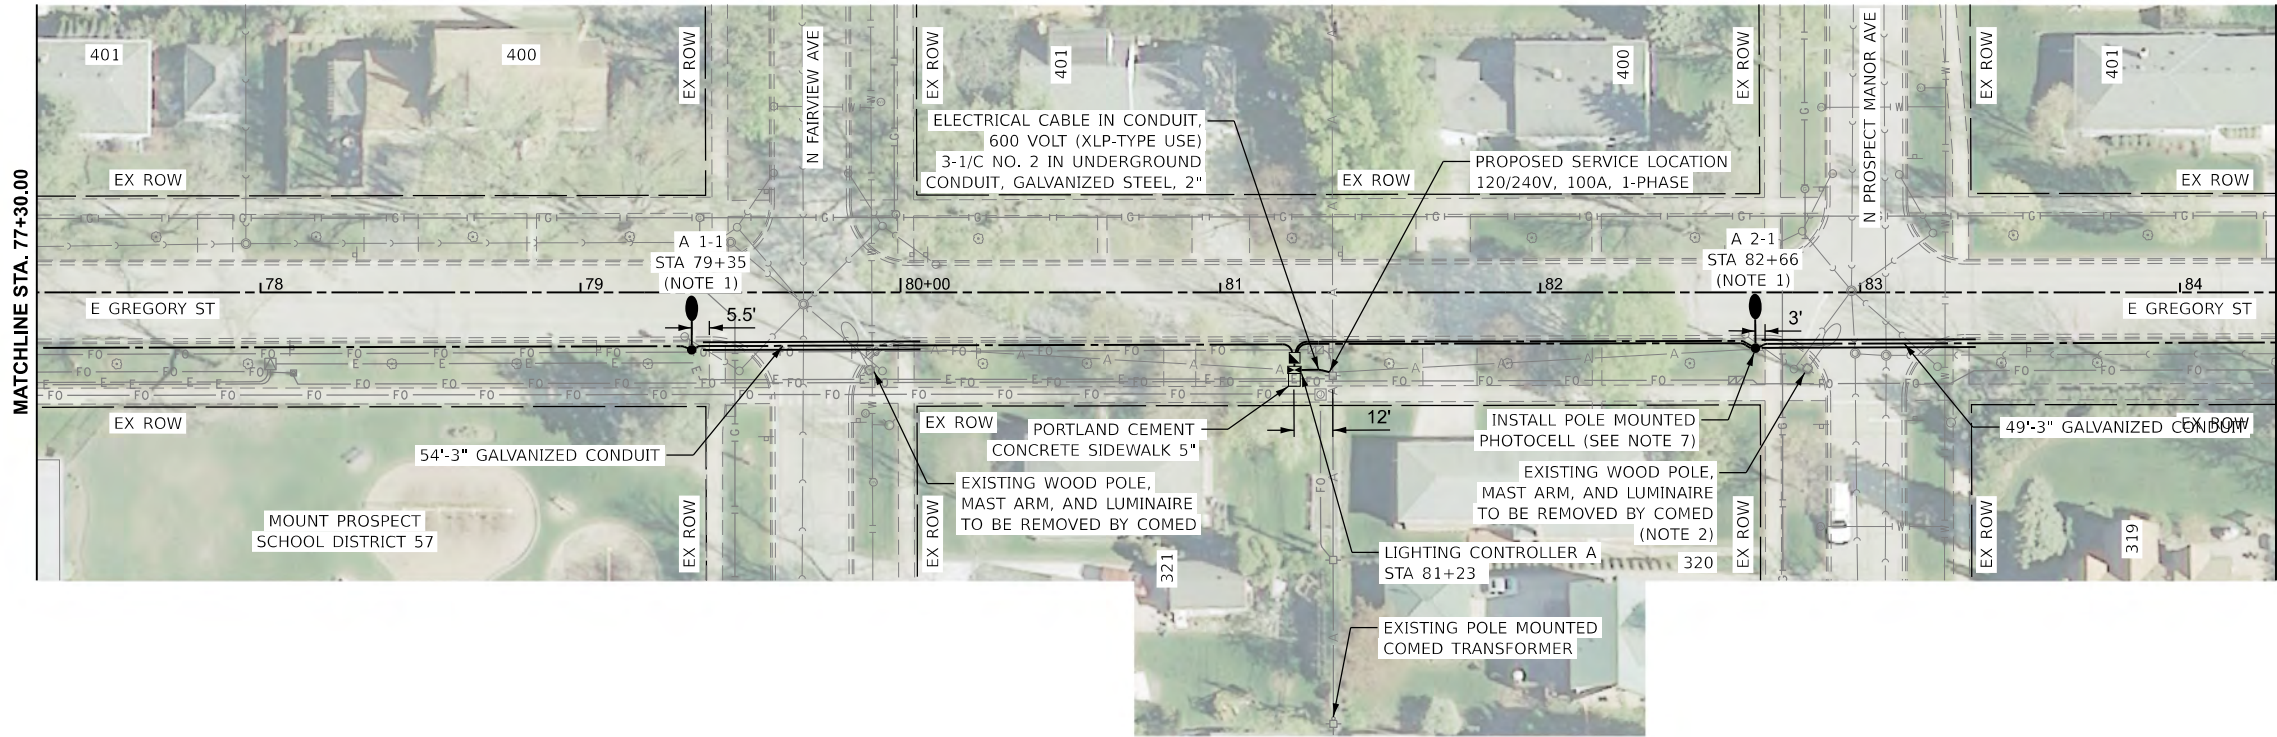


LEGEND

- EXISTING LIGHT POLE AND LUMINAIRE
- EXISTING MAST ARM AND LUMINAIRE MOUNTED ON UTILITY POLE
- EXISTING MAST ARM AND LUMINAIRE TO BE REMOVED
- LIGHT STANDARD, 25 FT. M.H., 10 FT. UNLESS NOTED OTHERWISE. CLAMP-ON MAST ARM, LED LUMINAIRE ON LIGHT POLE FOUNDATION, METAL
- PROPOSED HANDHOLE
- PROPOSED LIGHTING CONTROLLER
- PROPOSED UNIT DUCT WITH 2-1/C No. 6 & 1-1/C No. 8 GROUND, 600V (XLP-TYPE USE), 1" DIA. OR AS NOTED
- PROPOSED RIGID GALVANIZED STEEL CONDUIT
- CONTROLLER IDENTIFICATION (TYP.)
- CIRCUIT NUMBER (TYP.)
- POLE NUMBER (TYP.)

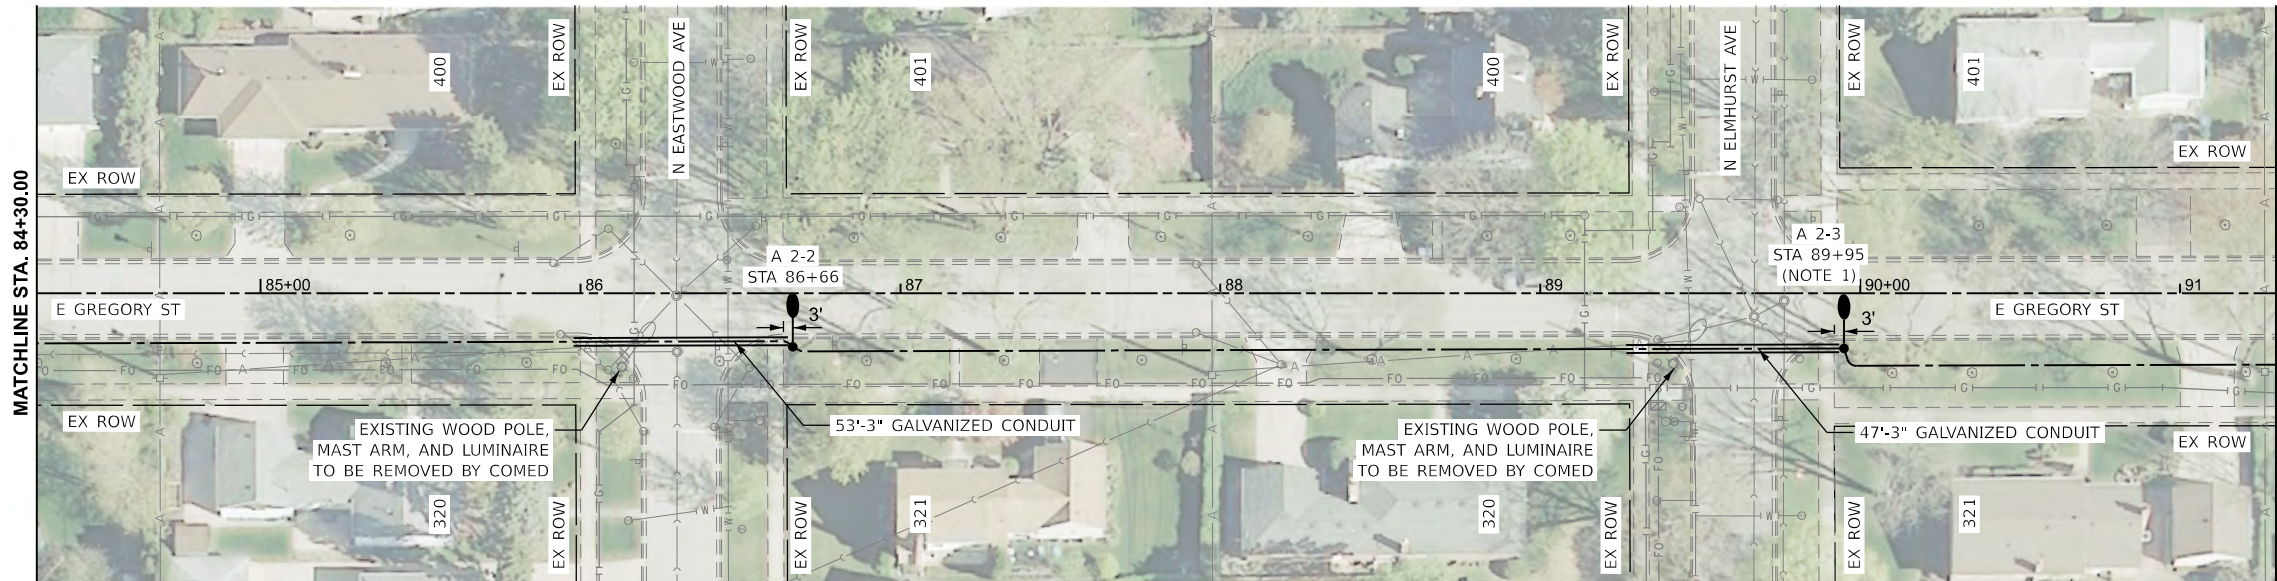

NOTES

 - VILLAGE TO RELOCATE EXISTING STREET SIGNS FROM SIGN POSTS TO PROPOSED LIGHT POLES.
- VILLAGE TO RELOCATE EXISTING STREET SIGNS FROM EXISTING WOOD LIGHT POLES TO SIGN POSTS.
- OFFSET LIGHTING UNITS NEAR DRIVEWAYS TO MAINTAIN 6 FEET FROM EDGE OF DRIVEWAY TO EDGE OF FOUNDATION UNLESS NOTED OTHERWISE.
- LIGHTING UNIT SETBACK SHALL BE 3 FEET FROM FACE OF CURB TO CENTER OF FOUNDATION UNLESS NOTED OTHERWISE.
- LUMINAIRES AT MID-BLOCK LOCATIONS SHALL HAVE OUTPUT CODE 050 AND LUMINAIRES AT INTERSECTIONS SHALL HAVE OUTPUT CODE 070.
- WATERMAIN LOCATION SHALL BE VERIFIED IN THE FIELD PRIOR TO CONSTRUCTION.
- POLE MOUNTED PHOTOCELL, 3-1/C #10 CABLE AND 1" DUCT INCLUDED IN THE COST OF LIGHTING CONTROLLER.



MODEL: Gregory - LTC203 [Sheet]
FILE NAME: c:\paw-cs\project\0105049\022144.01-shlt-LTG.dgn




PLOT DATE = 7/2/2026	USER NAME = amarotta	DESIGNED - AM	REVISED -
		DRAWN - AM	REVISED -
		CHECKED - JMV	REVISED -
		DATE - 5/6/2026	REVISED -

**GREGORY STREET LIGHTING
VILLAGE OF MOUNT PROSPECT**

**GREGORY ST
PROPOSED LIGHTING PLAN**


SCALE: 1"=30' SHEET 3 OF 4 SHEETS STA. 77+50.00 TO STA. 91+50.00

F.A. RTE.	SECTION	COUNTY	TOTAL SHEETS	SHEET NO.
		COOK	17	14
CONTRACT NO.				
ILLINOIS FED. AID PROJECT				

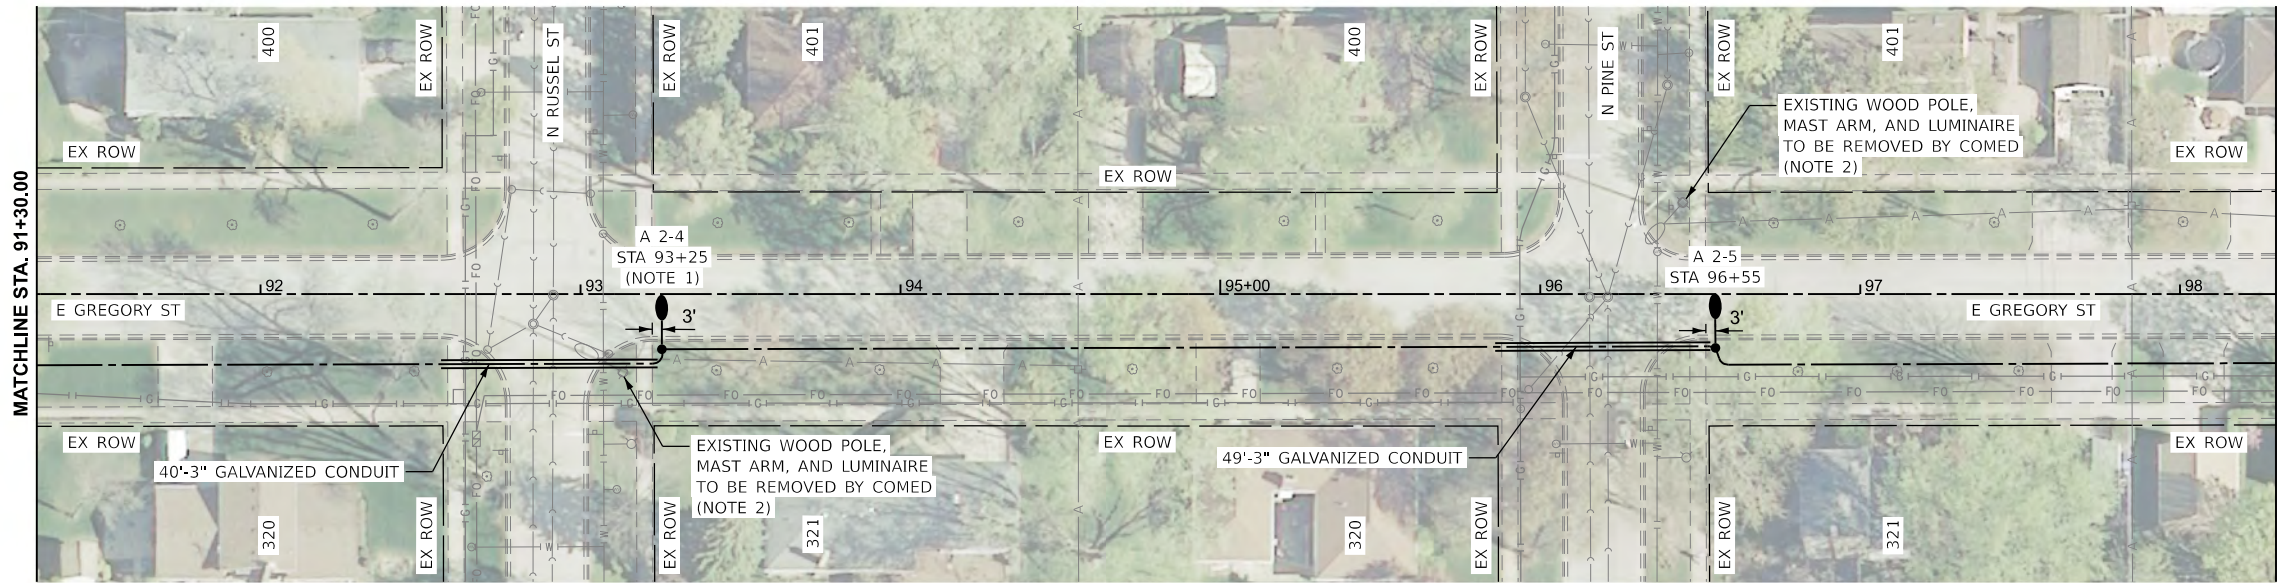


LEGEND

- EXISTING LIGHT POLE AND LUMINAIRE
- EXISTING MAST ARM AND LUMINAIRE MOUNTED ON UTILITY POLE
- EXISTING MAST ARM AND LUMINAIRE TO BE REMOVED
- LIGHT STANDARD, 25 FT. M.H., 10 FT. UNLESS NOTED OTHERWISE. CLAMP-ON MAST ARM, LED LUMINAIRE ON LIGHT POLE FOUNDATION, METAL
- PROPOSED HANDHOLE
- PROPOSED LIGHTING CONTROLLER
- PROPOSED UNIT DUCT WITH 2-1/C No. 6 & 1-1/C No. 8 GROUND, 600V (XLP-TYPE USE), 1" DIA. OR AS NOTED
- PROPOSED RIGID GALVANIZED STEEL CONDUIT
- CONTROLLER IDENTIFICATION (TYP.)
- CIRCUIT NUMBER (TYP.)
- POLE NUMBER (TYP.)

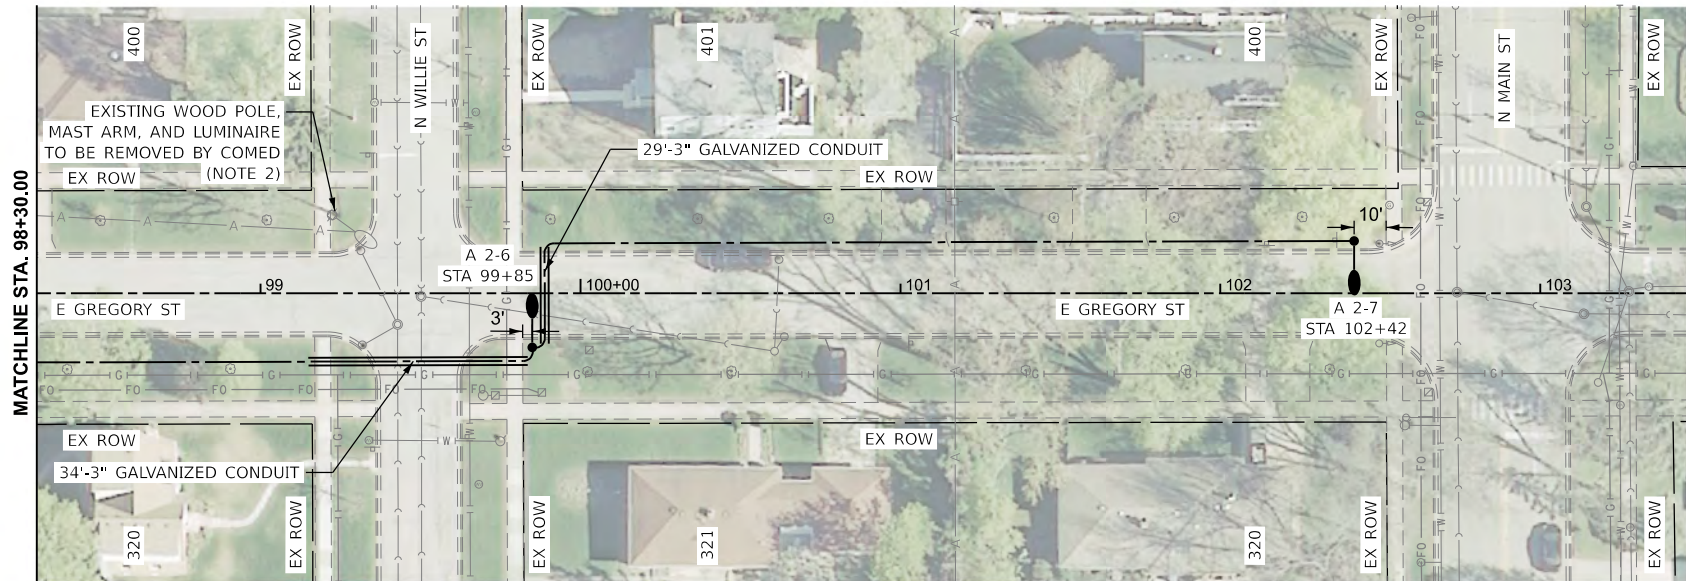

NOTES

 - VILLAGE TO RELOCATE EXISTING STREET SIGNS FROM SIGN POSTS TO PROPOSED LIGHT POLES.
- VILLAGE TO RELOCATE EXISTING STREET SIGNS FROM EXISTING WOOD LIGHT POLES TO SIGN POSTS.
- OFFSET LIGHTING UNITS NEAR DRIVEWAYS TO MAINTAIN 6 FEET FROM EDGE OF DRIVEWAY TO EDGE OF FOUNDATION UNLESS NOTED OTHERWISE.
- LIGHTING UNIT SETBACK SHALL BE 3 FEET FROM FACE OF CURB TO CENTER OF FOUNDATION UNLESS NOTED OTHERWISE.
- LUMINAIRES AT MID-BLOCK LOCATIONS SHALL HAVE OUTPUT CODE 050 AND LUMINAIRES AT INTERSECTIONS SHALL HAVE OUTPUT CODE 070.
- WATERMAIN LOCATION SHALL BE VERIFIED IN THE FIELD PRIOR TO CONSTRUCTION.
- POLE MOUNTED PHOTOCCELL, 3-1/C #10 CABLE AND 1" DUCT INCLUDED IN THE COST OF LIGHTING CONTROLLER.



MODEL: Gregory - LTC204 [Sheet]
FILE NAME: c:\paw-cg\procd\01050409\022144.01-sjh-LTG.dgn




USER NAME = jvondra	DESIGNED - AM	REVISED -
	DRAWN - AM	REVISED -
	CHECKED - JMV	REVISED -
	DATE - 5/6/2026	REVISED -
PLOT DATE = 6/15/2026		

GREGORY STREET LIGHTING VILLAGE OF MOUNT PROSPECT

GREGORY ST PROPOSED LIGHTING PLAN

SCALE: 1"=30' SHEET 4 OF 4 SHEETS STA. 91+50.00 TO STA. 105+50.00

F.A. RTE.	SECTION	COUNTY	TOTAL SHEETS	SHEET NO.
		COOK	17	15
CONTRACT NO.				
ILLINOIS FED. AID PROJECT				

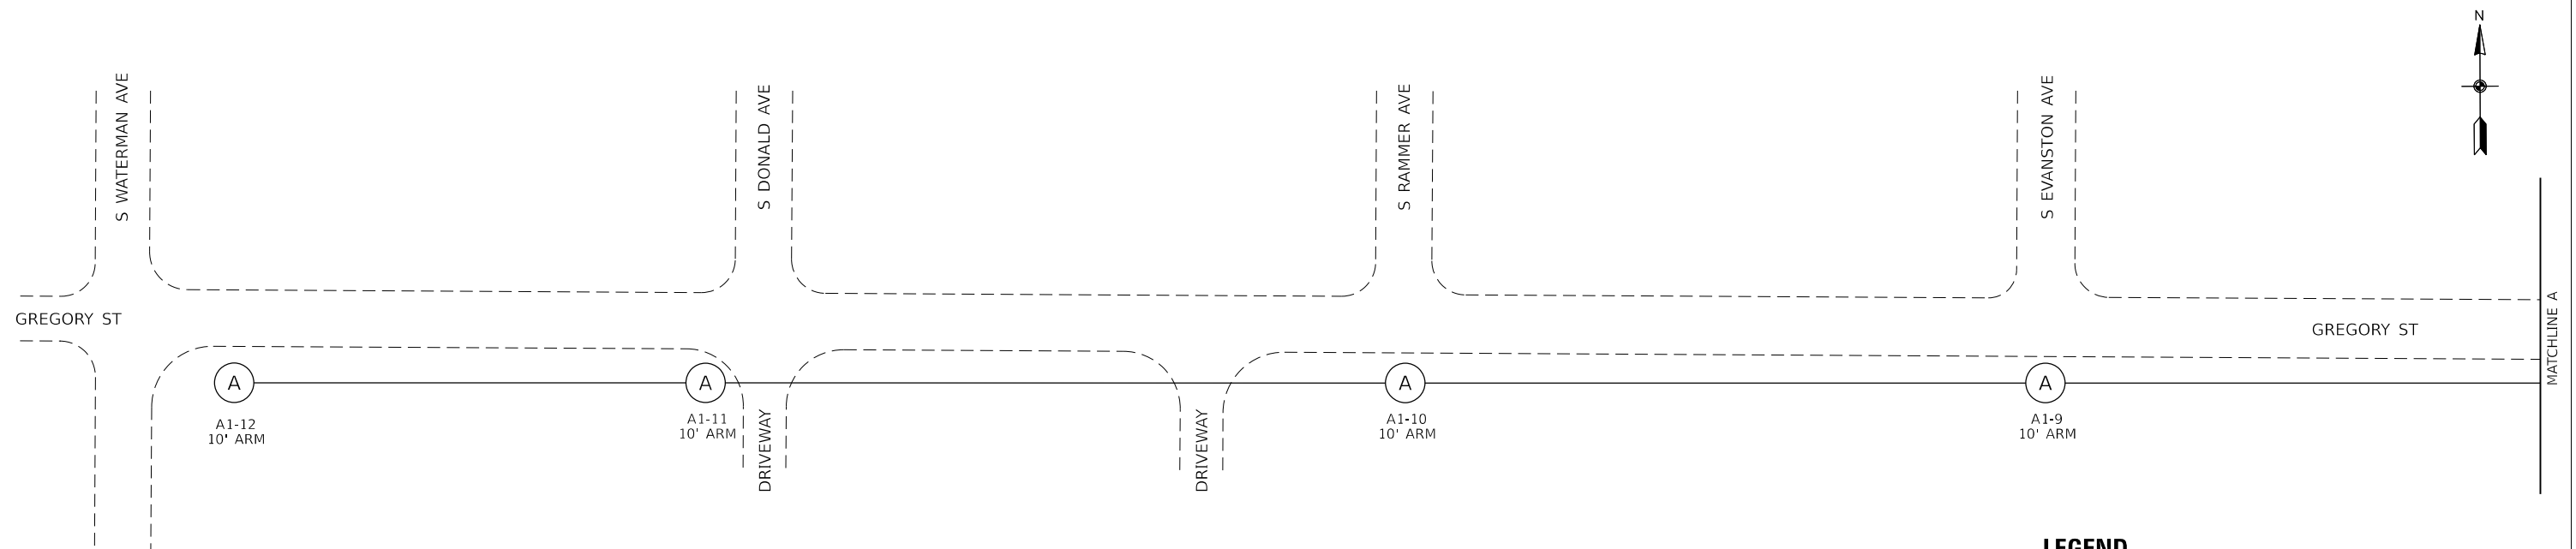

LEGEND

- | | |
|---|--|
| A | LIGHT STANDARD, ALUMINUM, 25' M.H., ARM LENGTH AS NOTED, CLAMP-ON MAST ARM, WITH 66W LED LUMINAIRE |
| B | LIGHT STANDARD, ALUMINUM, 25' M.H., ARM LENGTH AS NOTED, CLAMP-ON MAST ARM, WITH 43W LED LUMINAIRE |





PROPOSED LIGHTING CONTROLLER, 120/240V, 1-PHASE, 100A



PROPOSED HANDHOLE

UNIT DUCT, 2-1/C #6, 1/C #8 GROUND, 600V (XLP-TYPE USE), 1" DIAMETER POLYETHYLENE

- A - EXISTING AERIAL CABLE

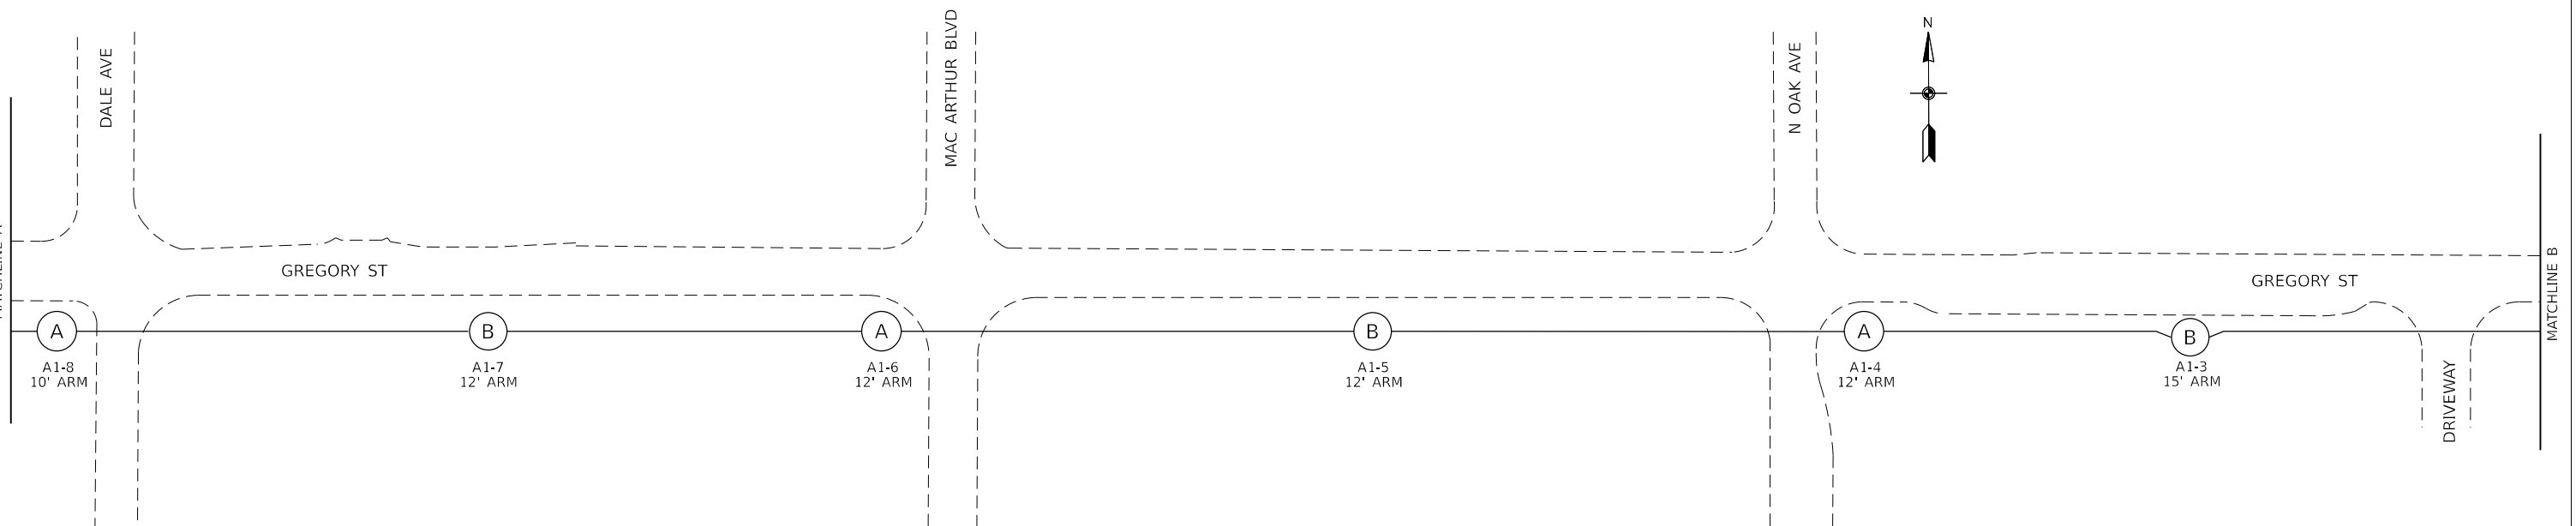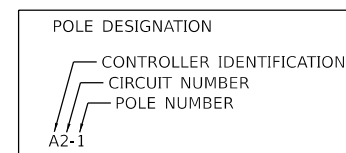

USER NAME = Personal	DESIGNED - AM	REVISED -
	DRAWN - AM	REVISED -
	CHECKED - JMV	REVISED -
PLOT DATE = 7/2/2026	DATE - 5/6/2026	REVISED -

**GREGORY STREET LIGHTING
VILLAGE OF MOUNT PROSPECT**

SINGLE LINE DIAGRAM

SCALE:	N.T.S.	SHEET 1	OF 2	SHEETS	STA.	TO STA.
--------	--------	---------	------	--------	------	---------

F.A. RTE.	SECTION	COUNTY	TOTAL SHEETS	SHEET NO.
		COOK	17	16
CONTRACT NO.				
ILLINOIS		FED. AID PROJECT		

